
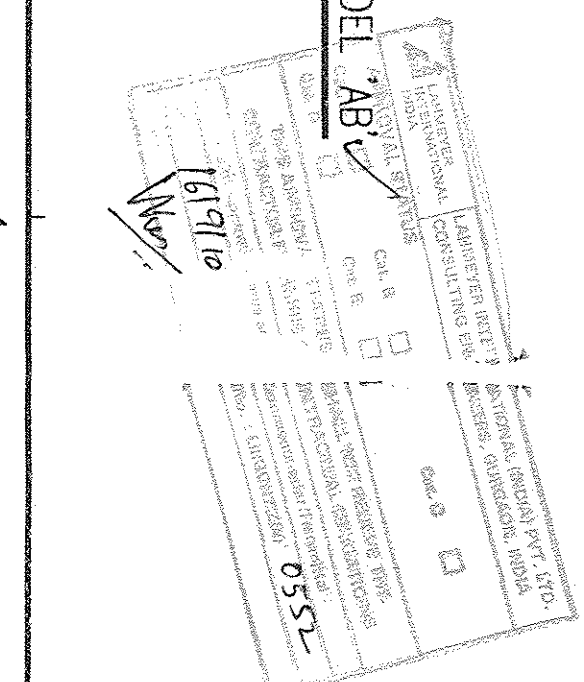
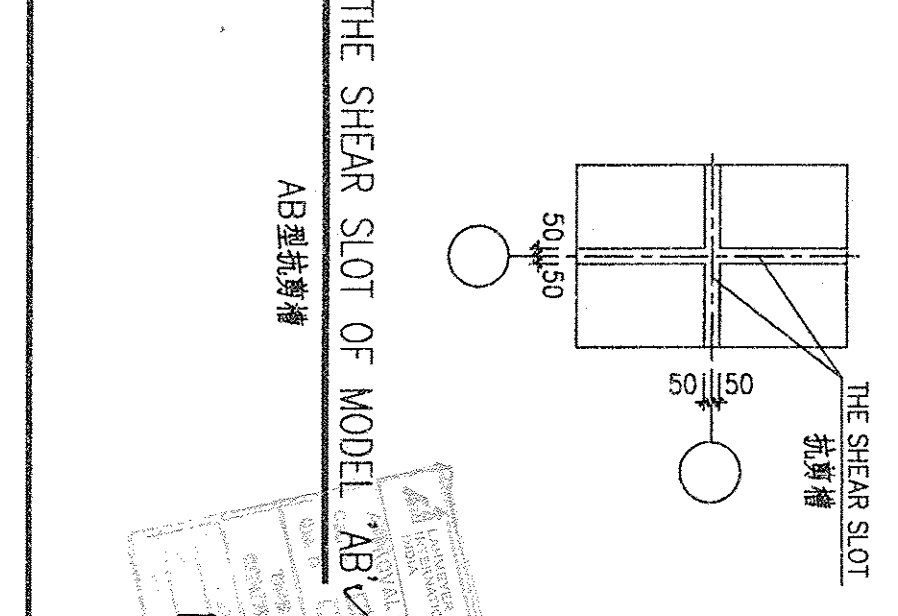
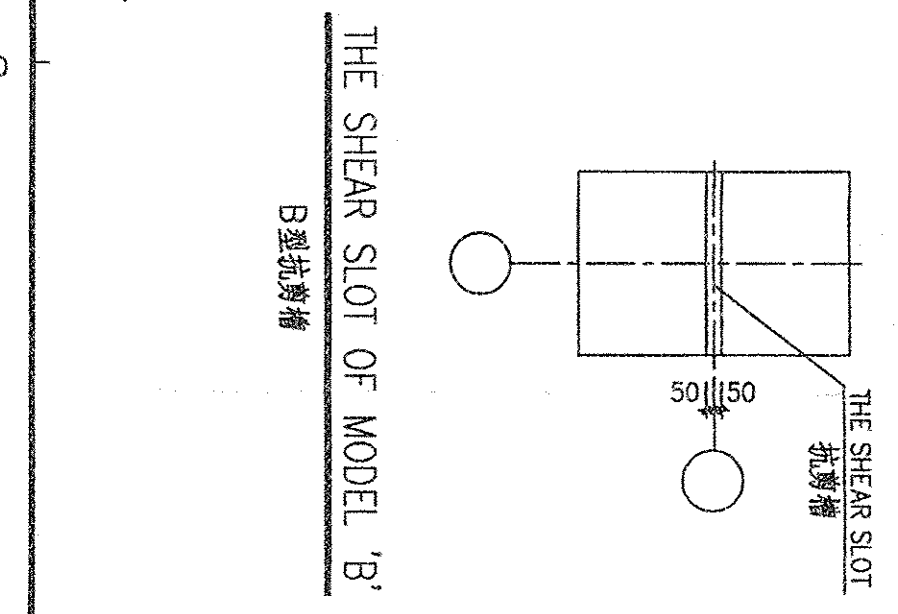
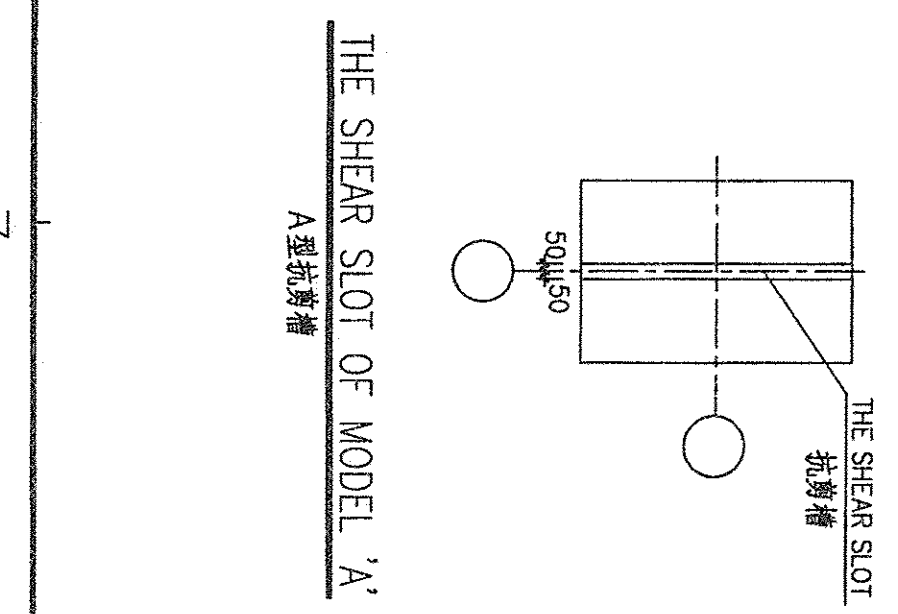


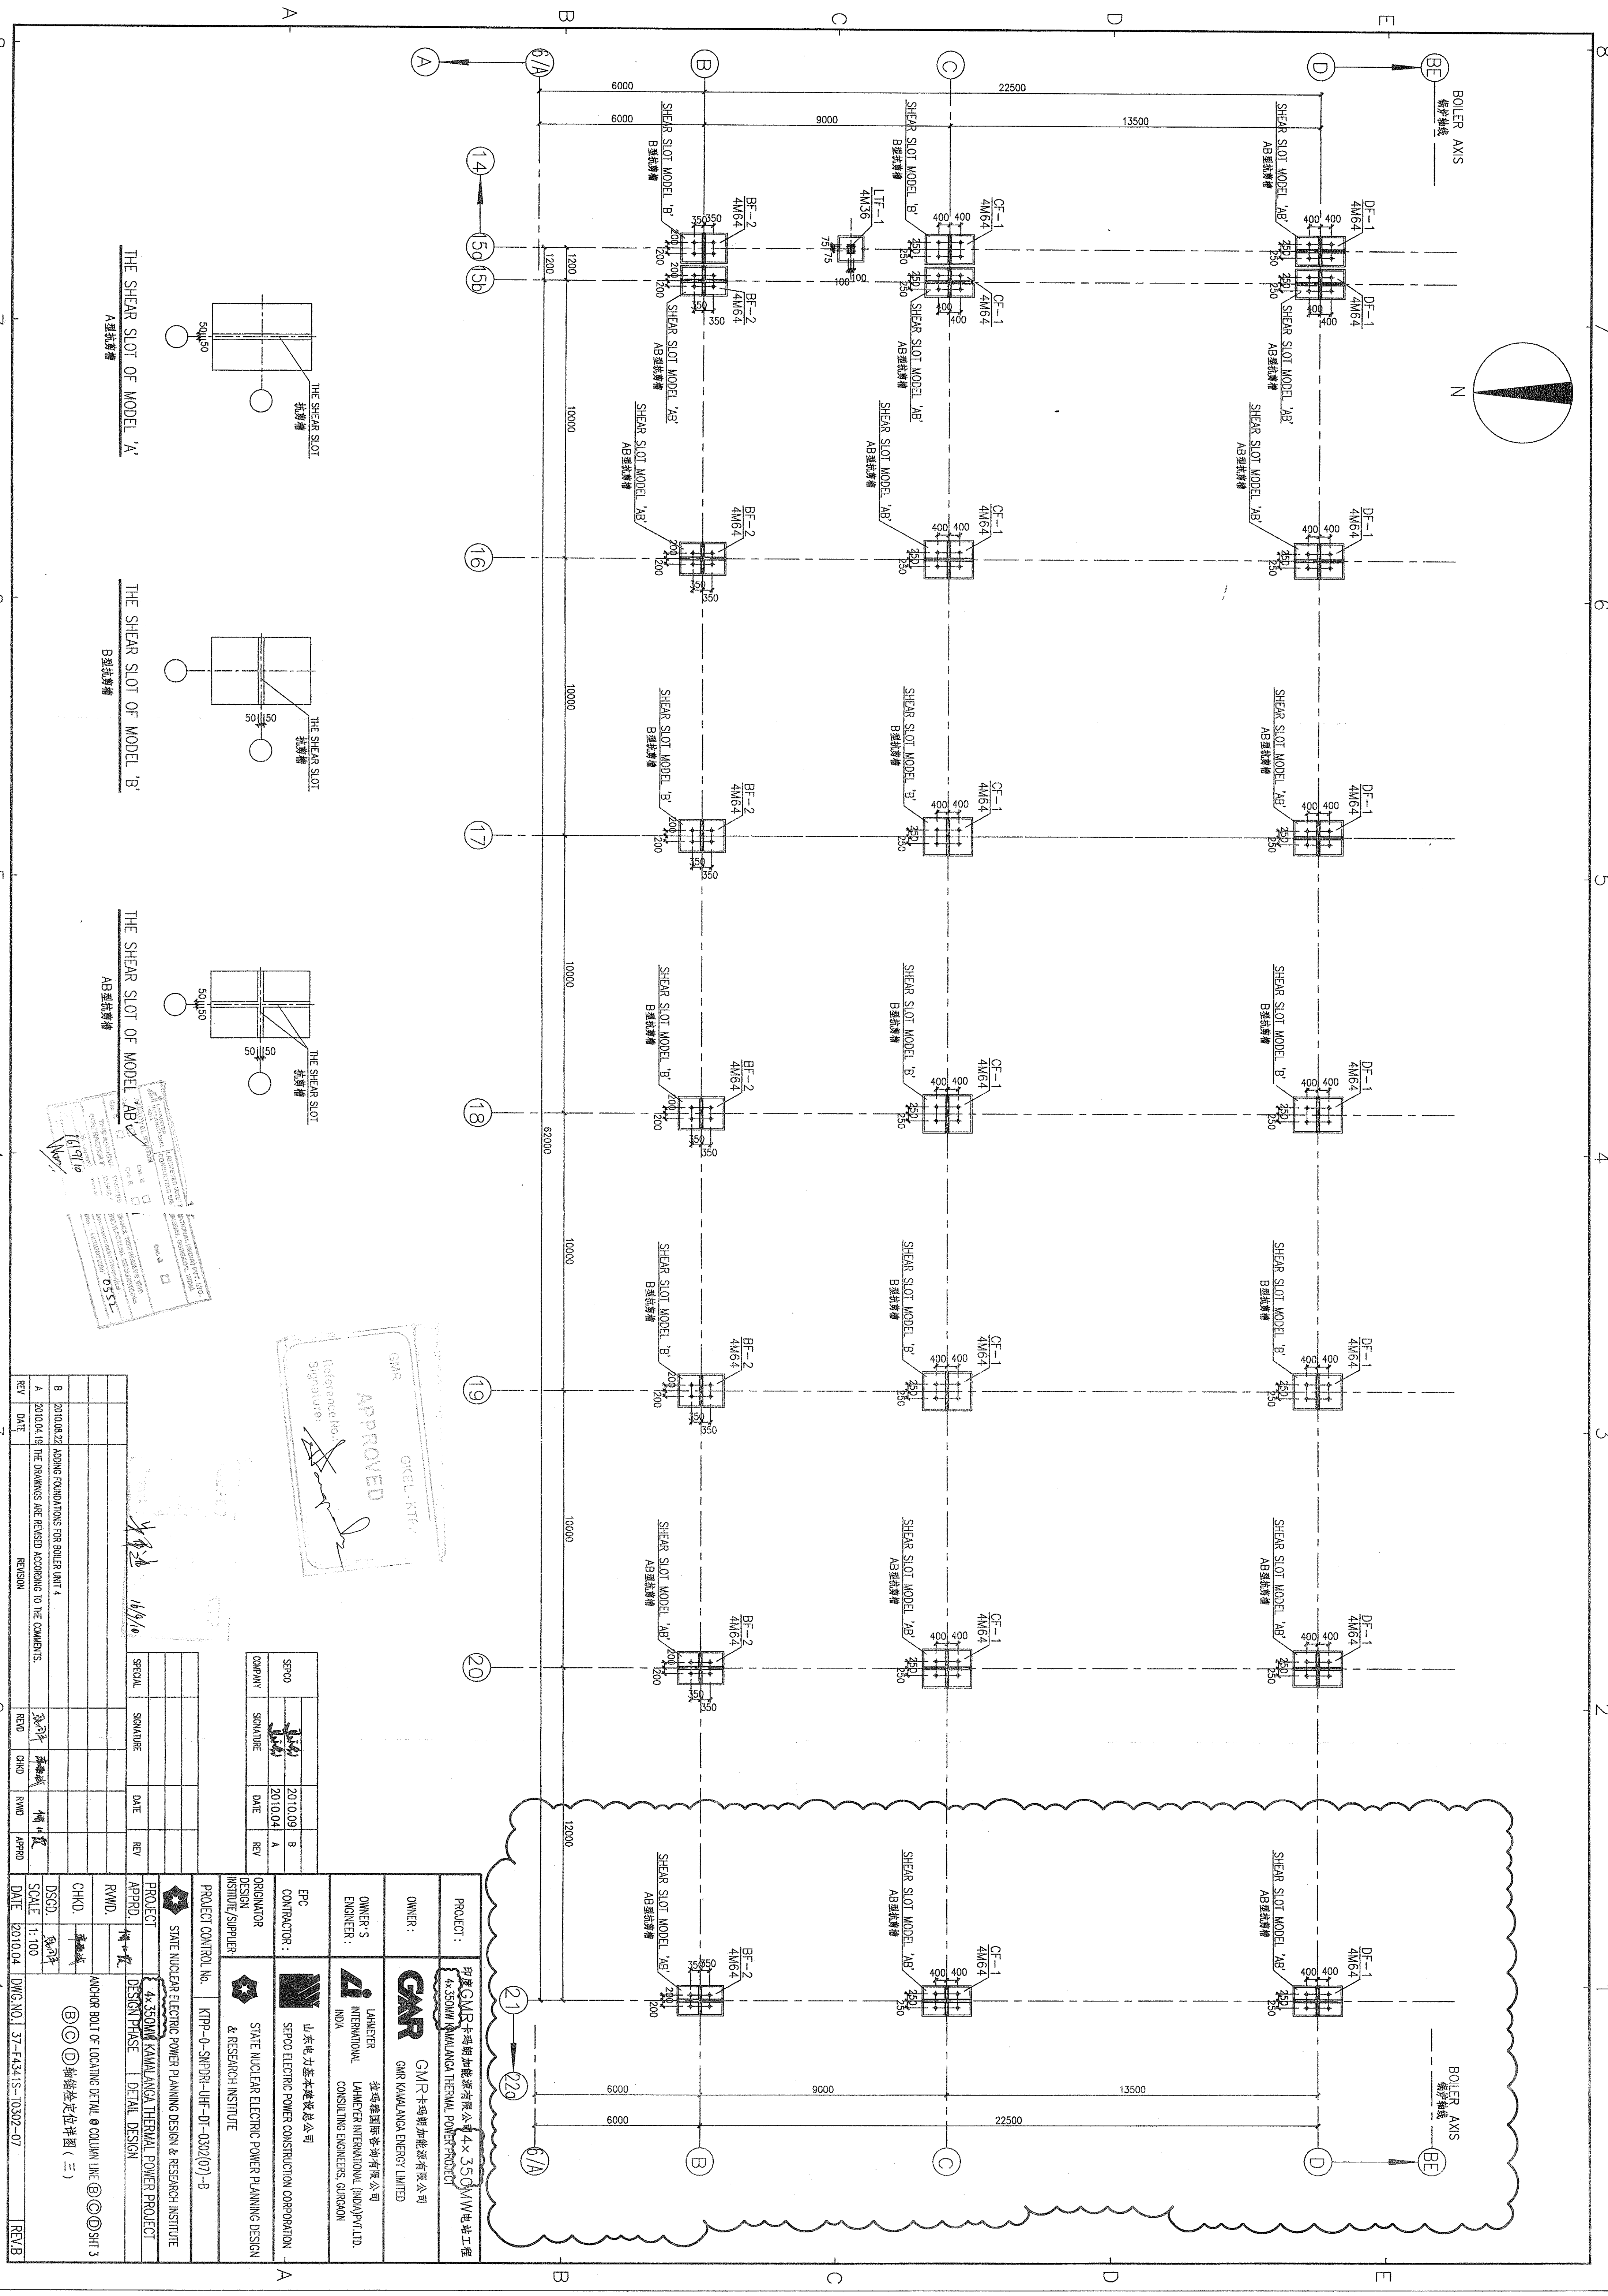

APPROVED

GMR GKEL-KTP

Reference No. _____

Signature: _____

REV	DATE	REVISION
A	2010.04.19	THE DRAWINGS ARE REVISED ACCORDING TO THE COMMENTS.

COMPANY	SIGNATURE	DATE	REV
SEPCO	[Signature]	2010.09	8
SEPCO	[Signature]	2010.04	A

PROJECT:	4x350MW KAMALANGA THERMAL POWER PROJECT
OWNER:	GMR KAMALANGA ENERGY LIMITED
OWNER'S ENGINEER:	LAHMER INTERNATIONAL (INDIA) PVT. LTD.
EPC CONTRACTOR:	SHANGHAI ELECTRIC POWER CONSTRUCTION CORPORATION
DESIGN INSTITUTE/SUPPLIER:	STATE NUCLEAR ELECTRIC POWER PLANNING DESIGN & RESEARCH INSTITUTE
PROJECT CONTROL No.	KTP-0-SNPR-UIF-DT-0302(07)-B
PROJECT:	STATE NUCLEAR ELECTRIC POWER PLANNING DESIGN & RESEARCH INSTITUTE
APPROD.	4x350MW KAMALANGA THERMAL POWER PROJECT
DESIGN PHASE	DETAIL DESIGN
CHKD.	[Signature]
DSGD.	[Signature]
SCALE	1:100
DATE	2010.04
DWG. NO.	37-F4341S-10302-07
REV/B	

ANCHOR BOLT OF LOCATING DETAIL @ COLUMN LINE ③ ④ ⑤ SH 3

③ ④ ⑤ 轴端定位详图 (三)