
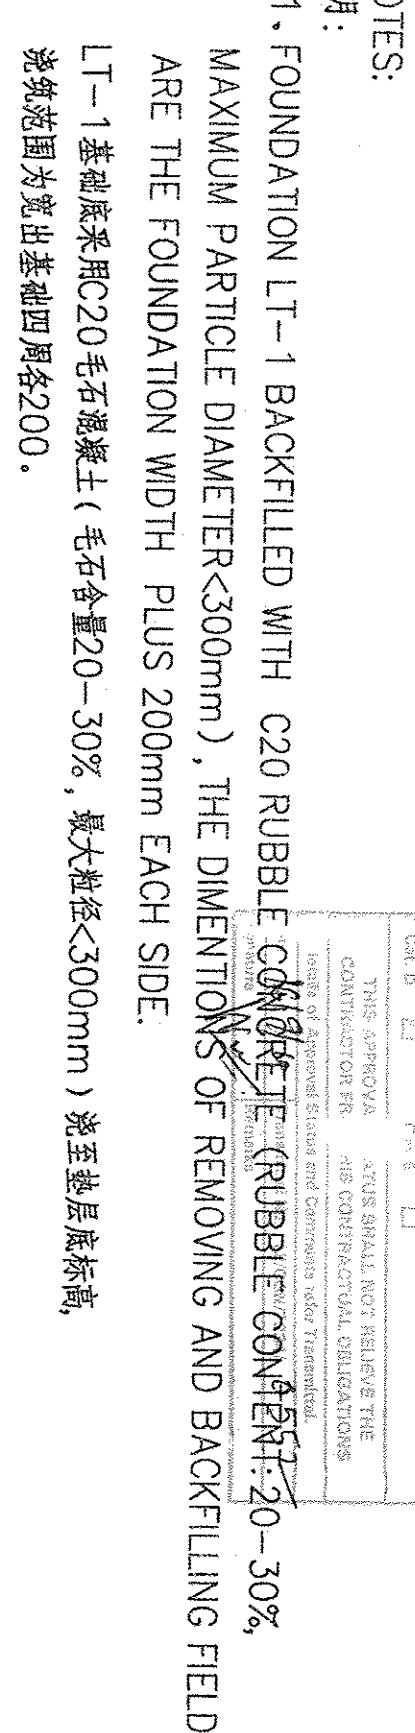
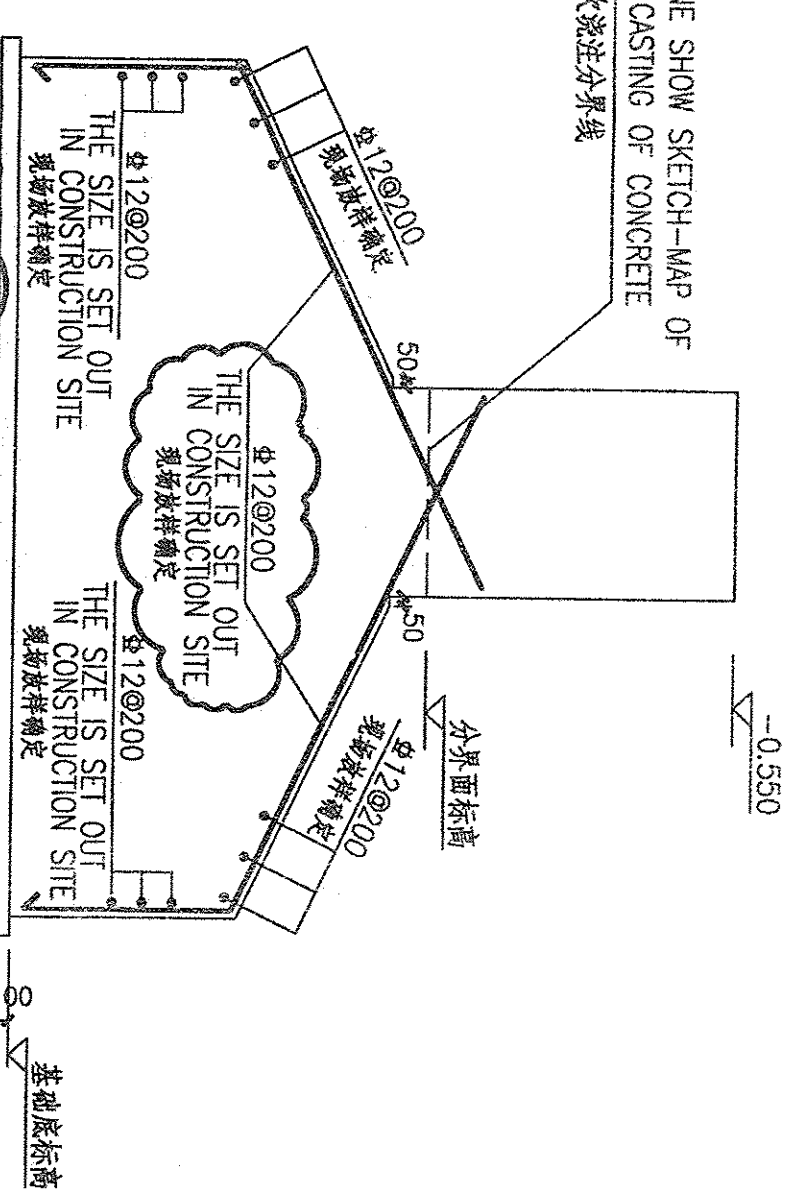
 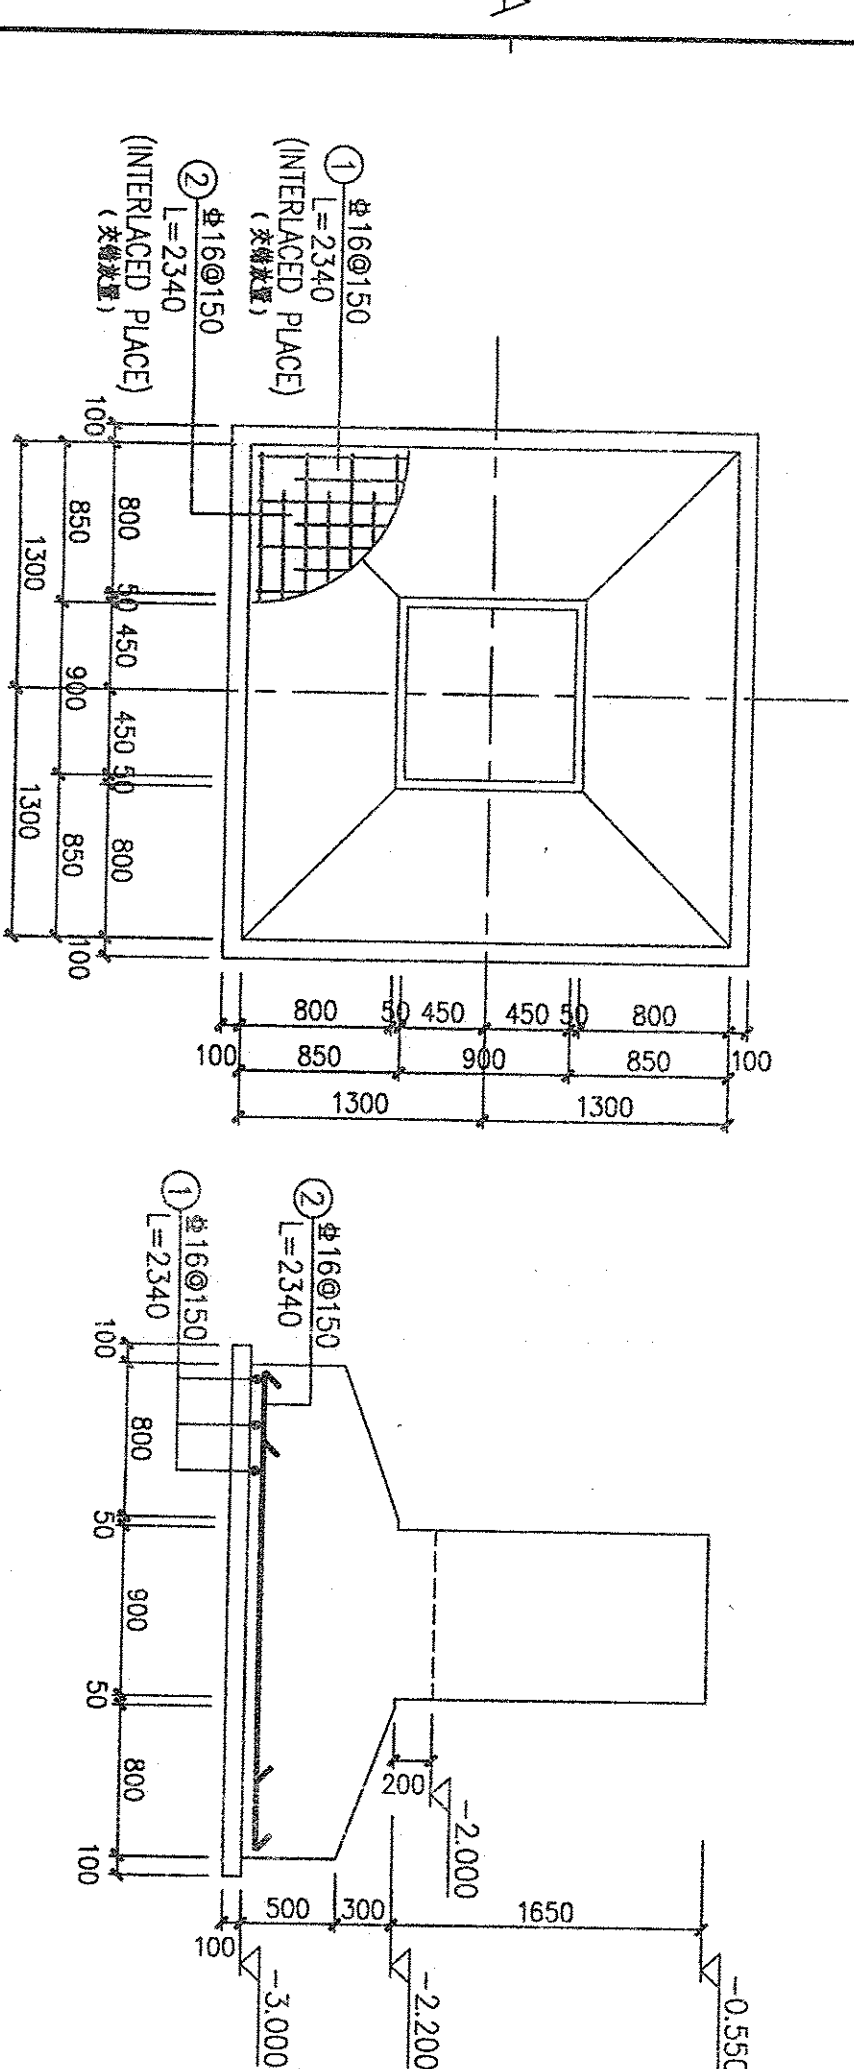

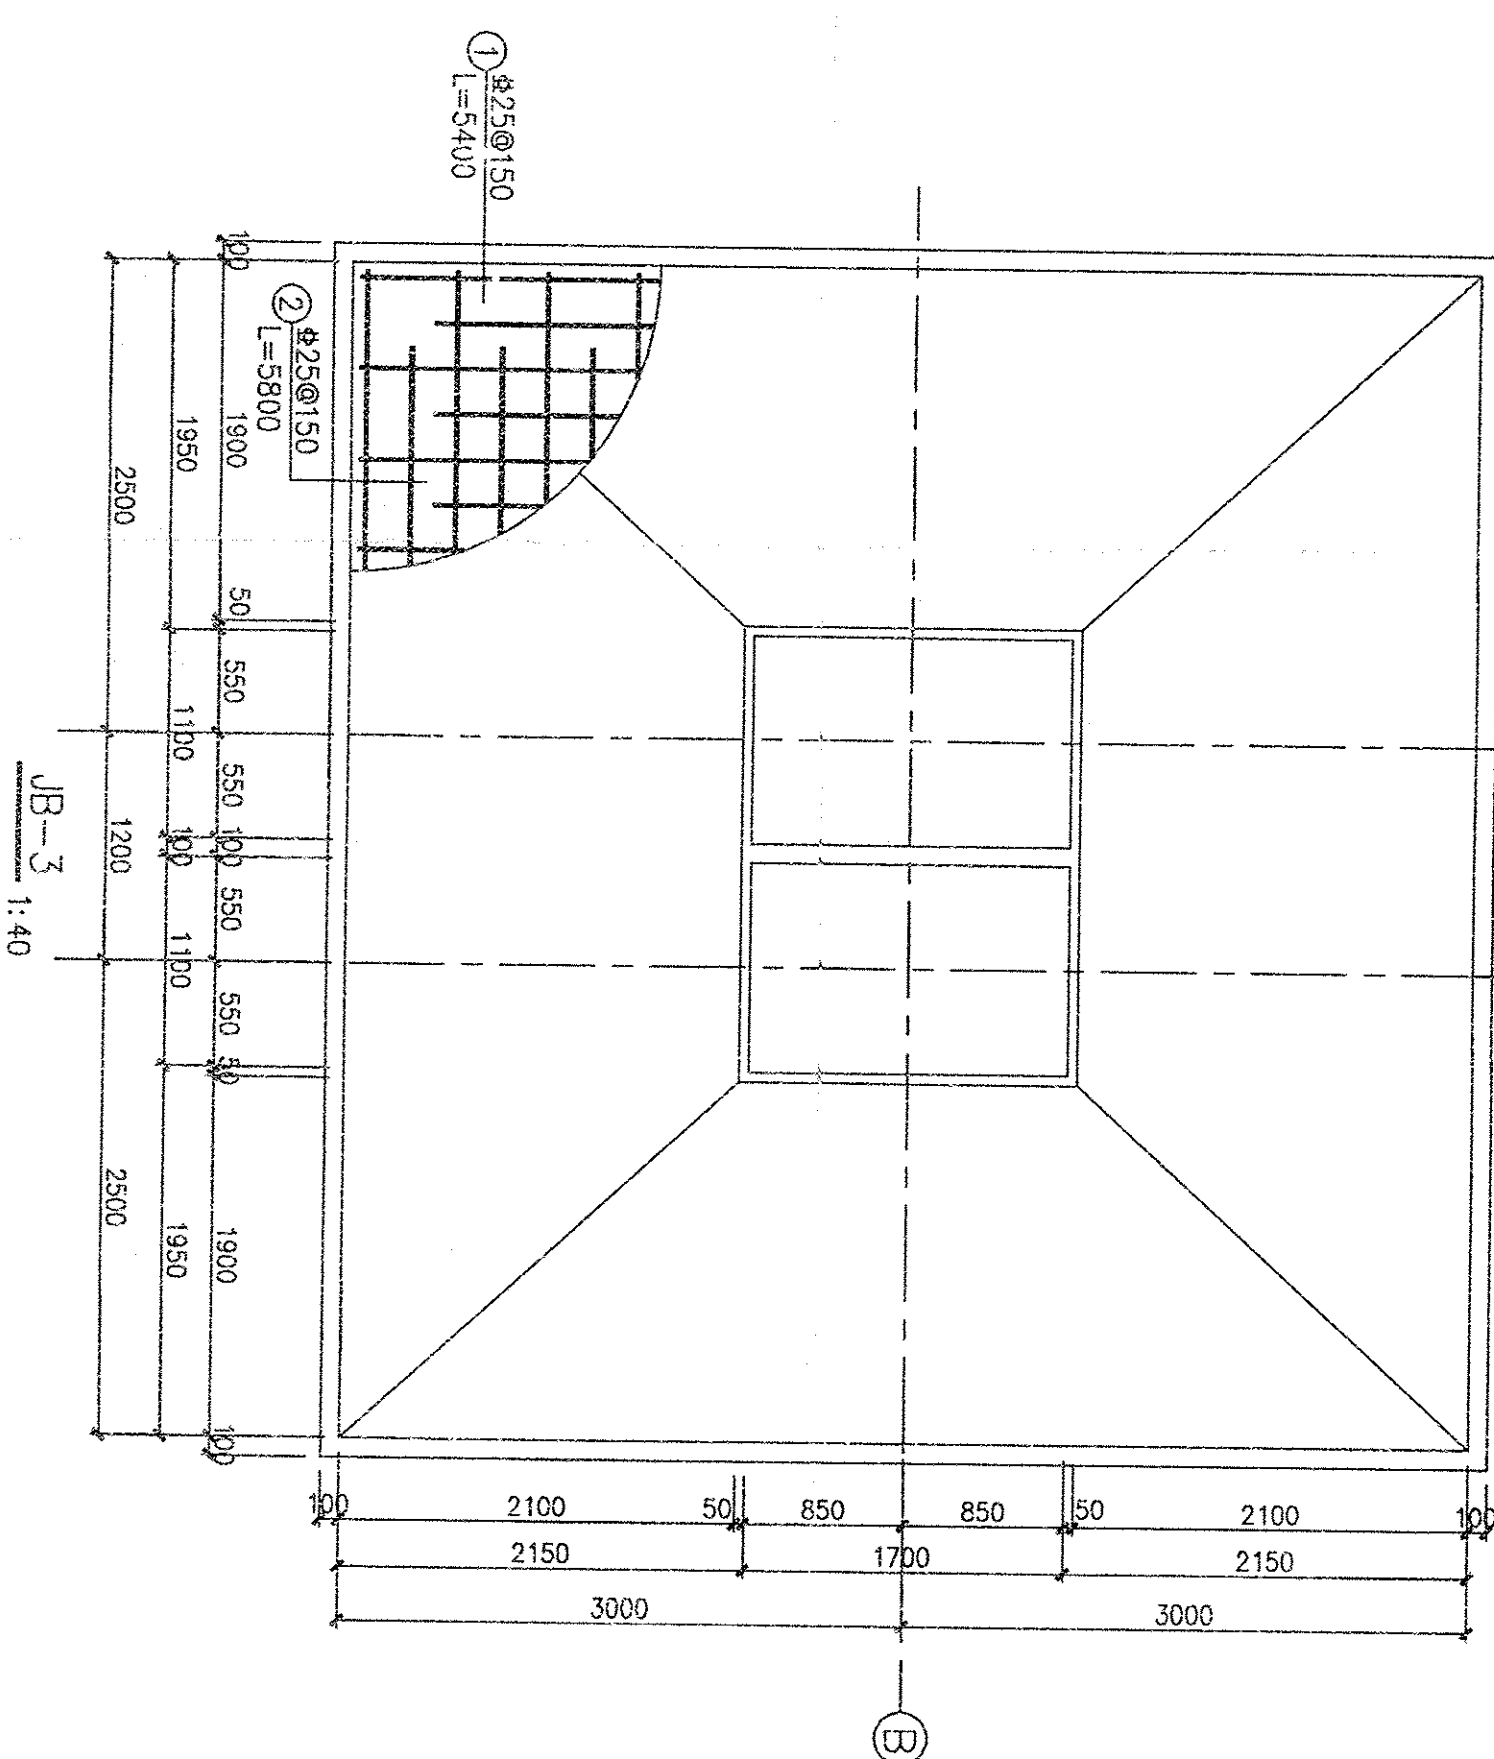
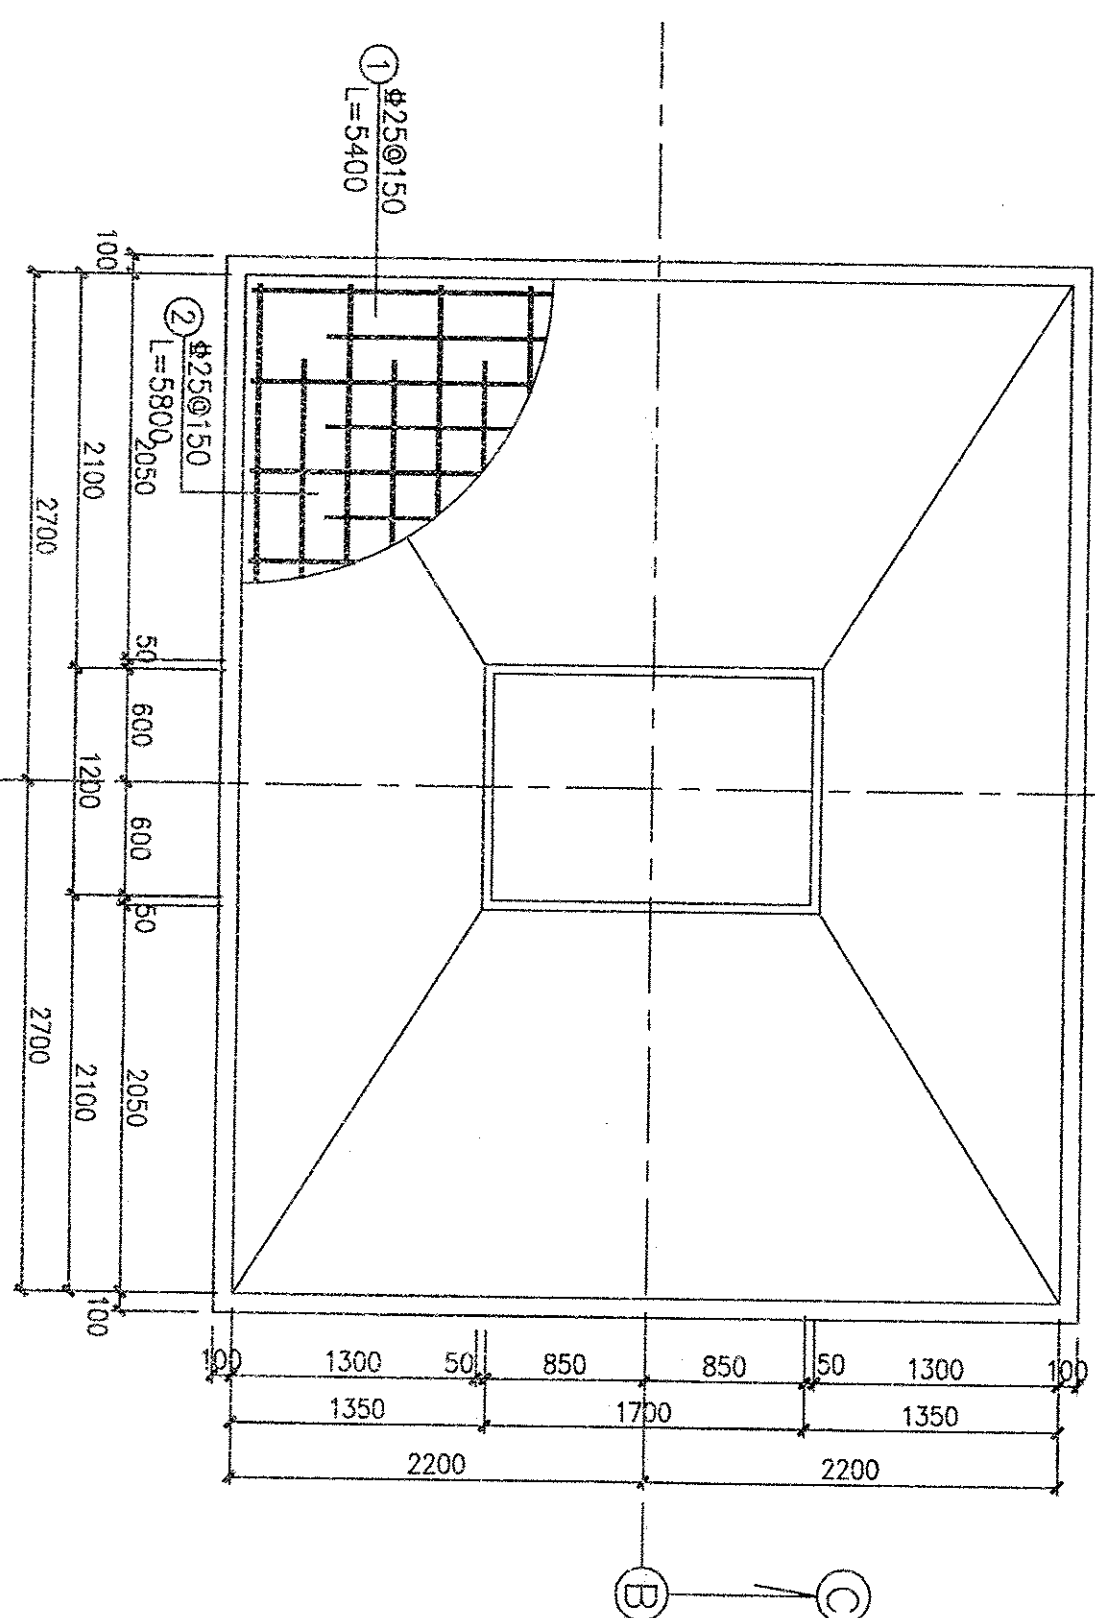
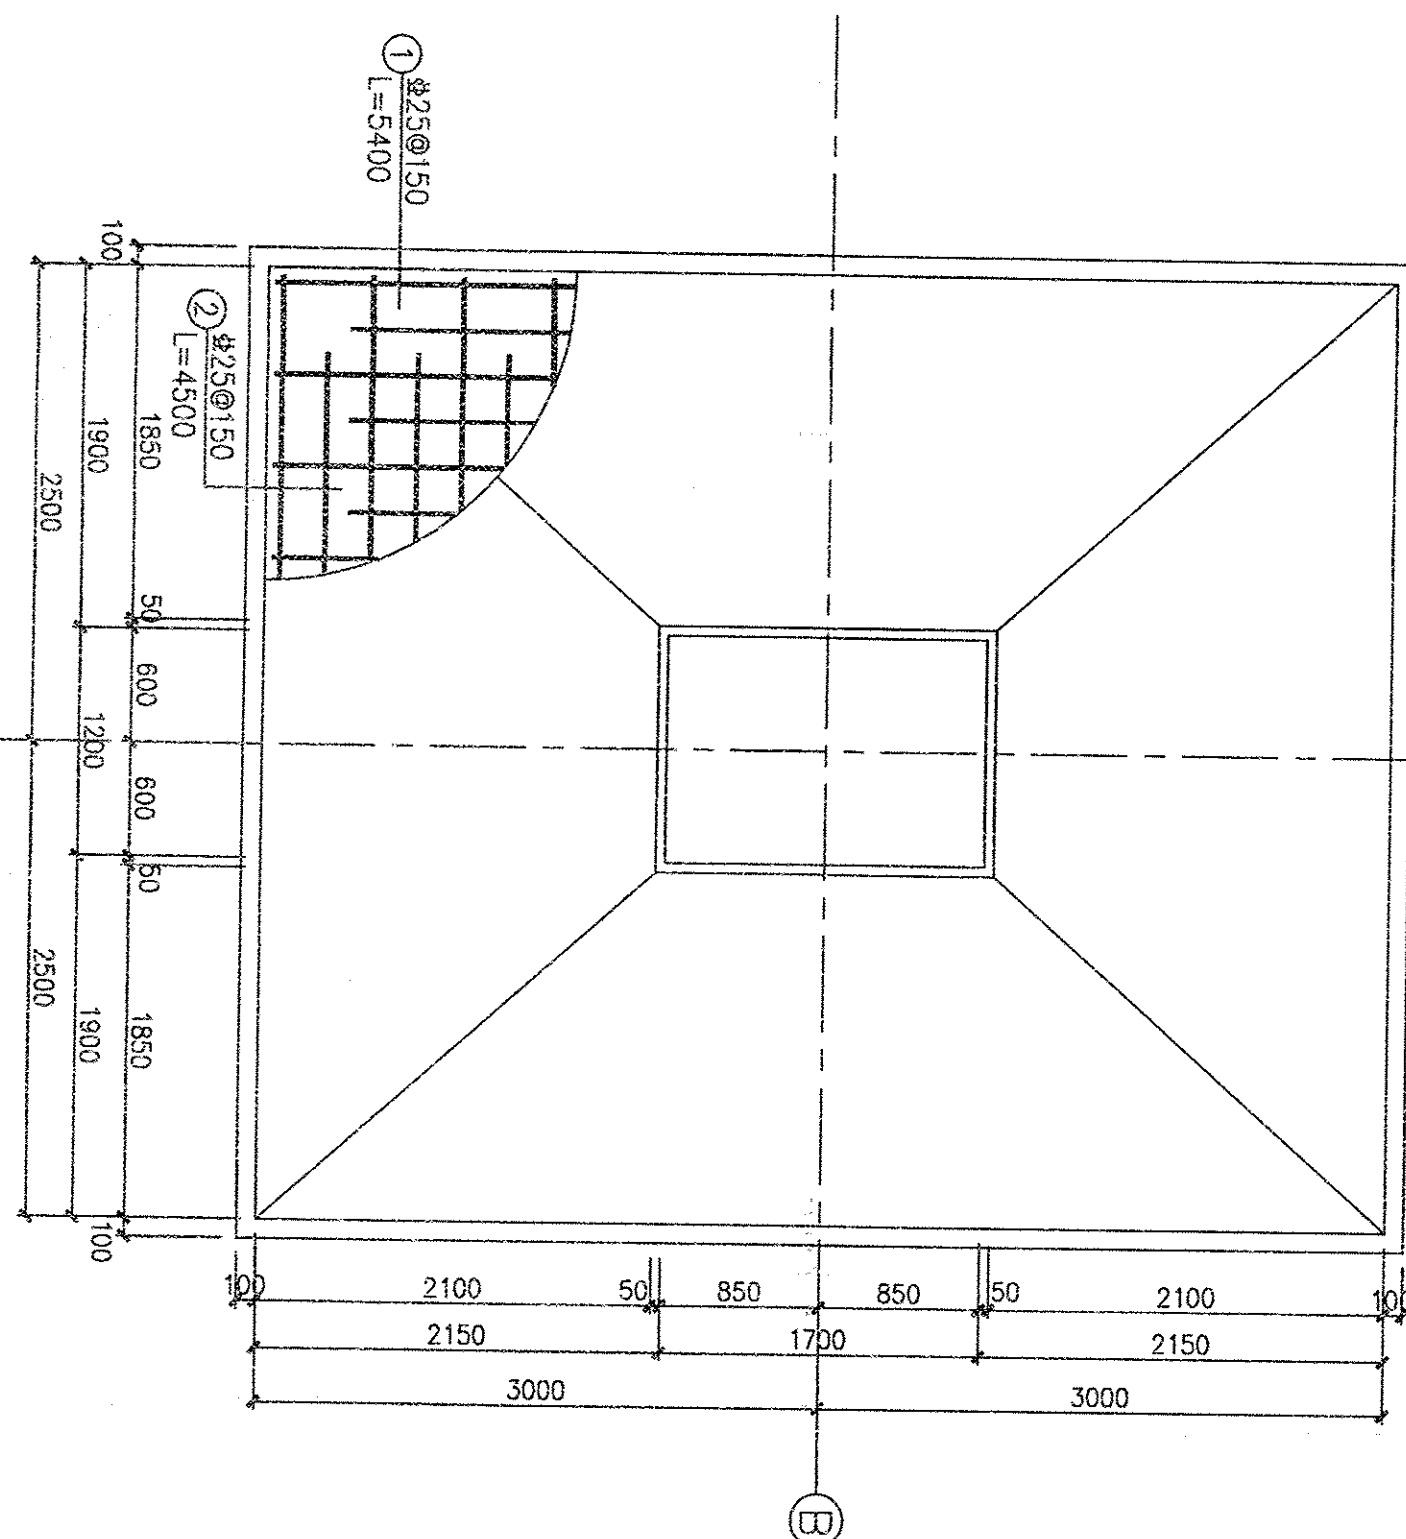
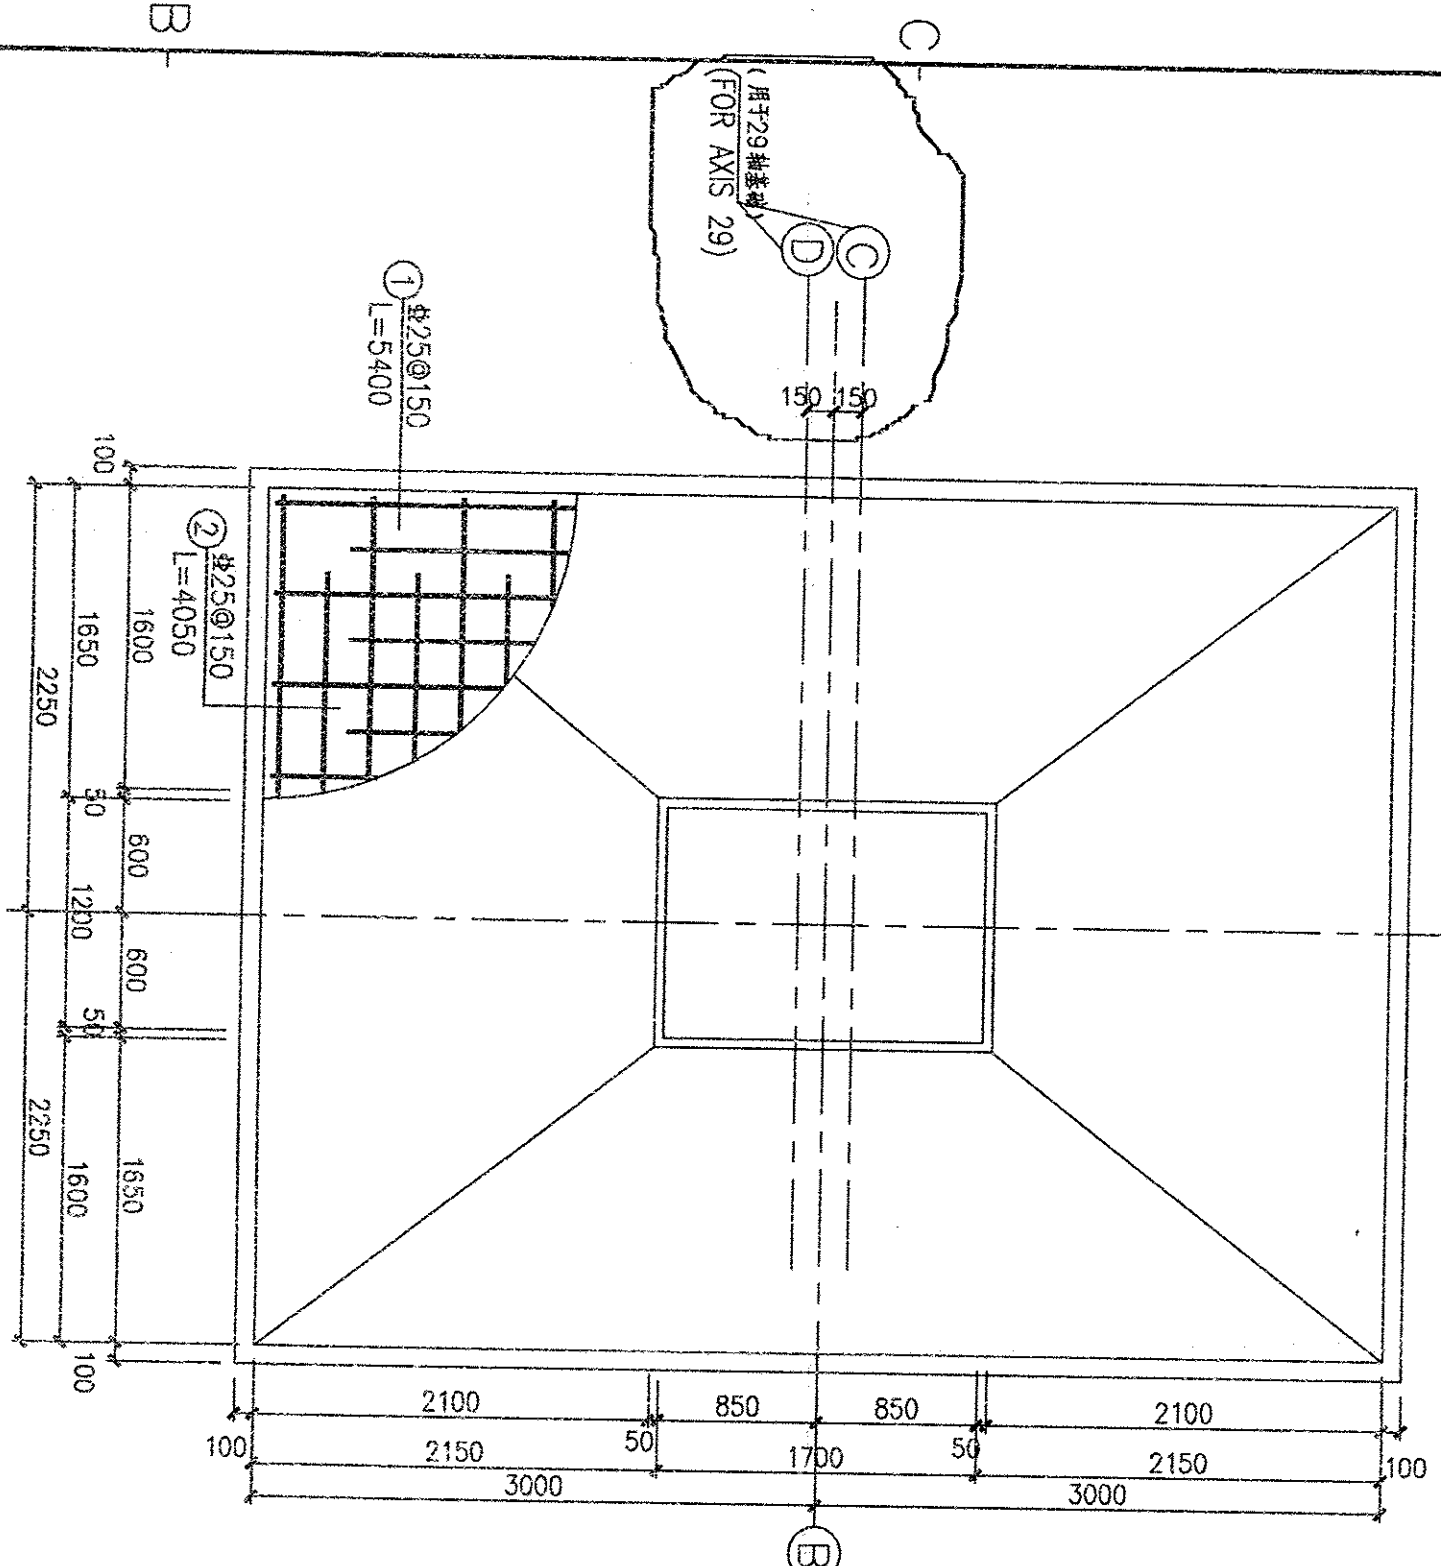
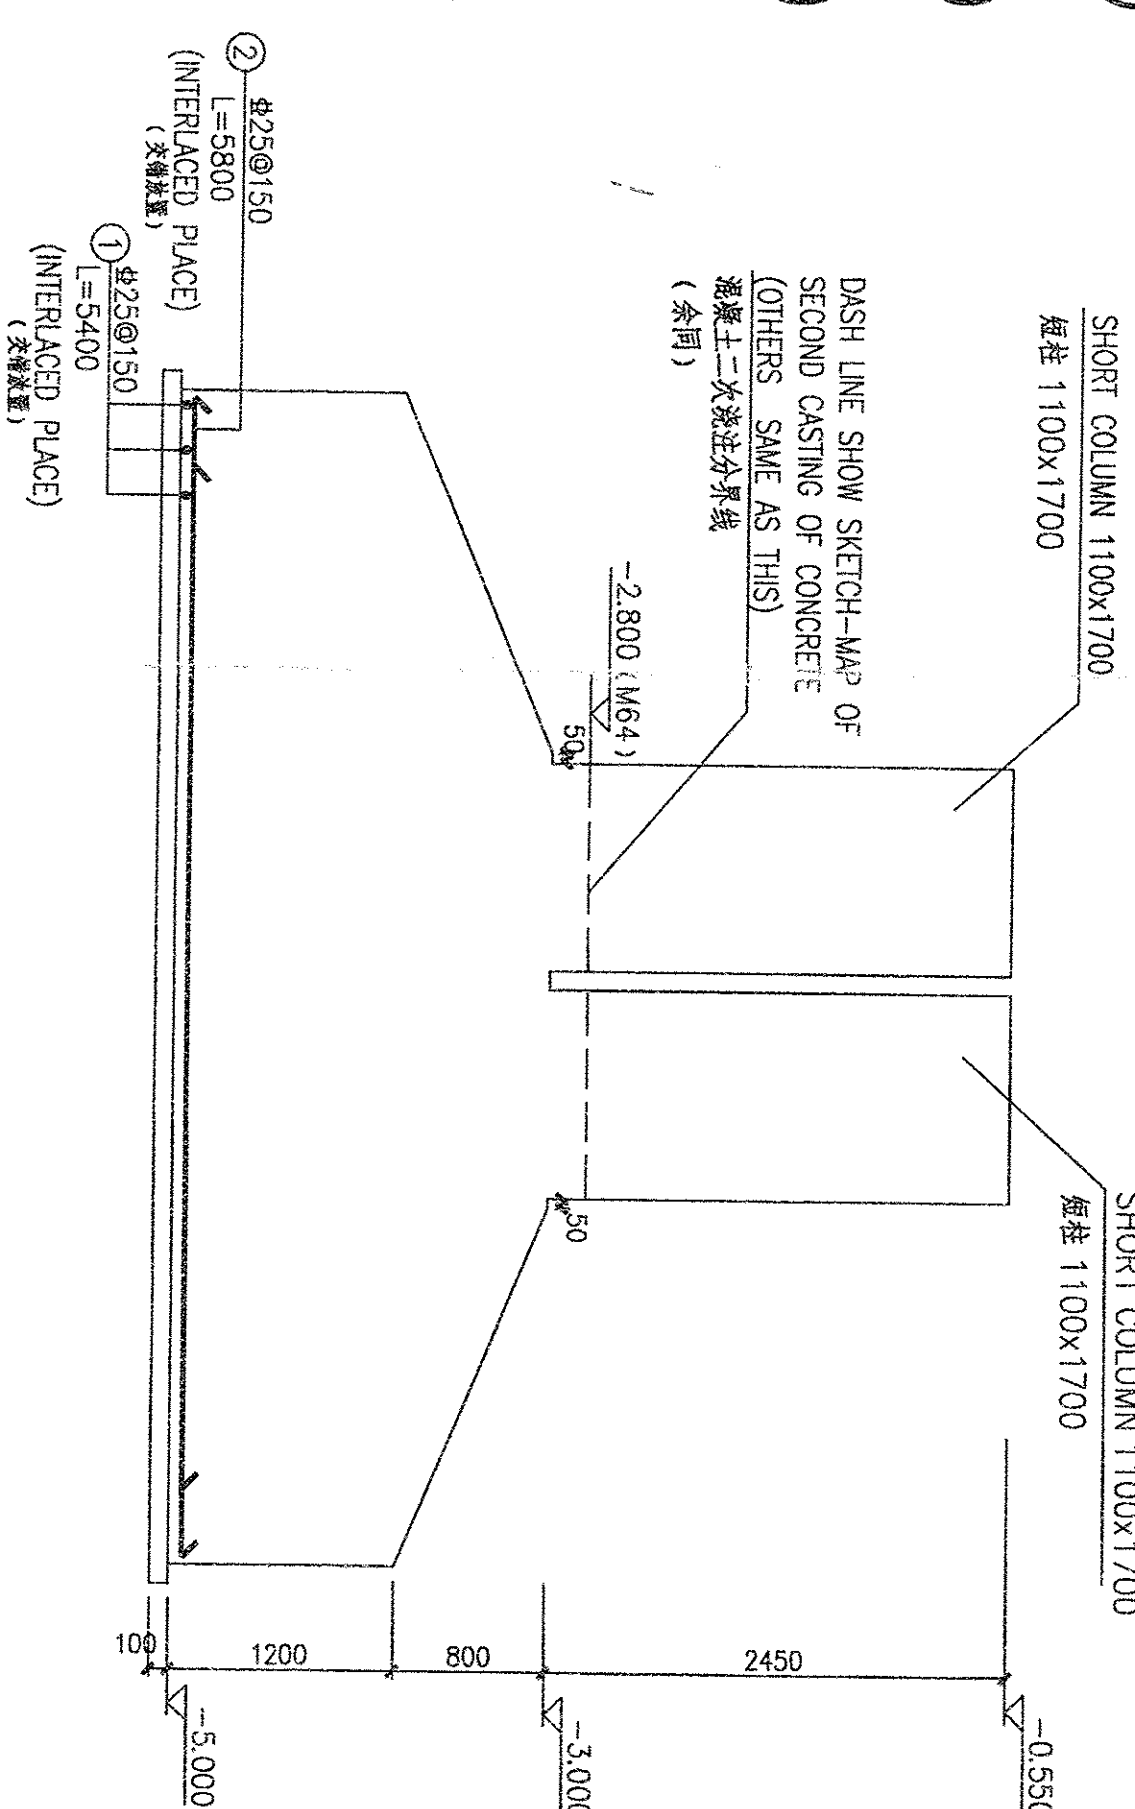
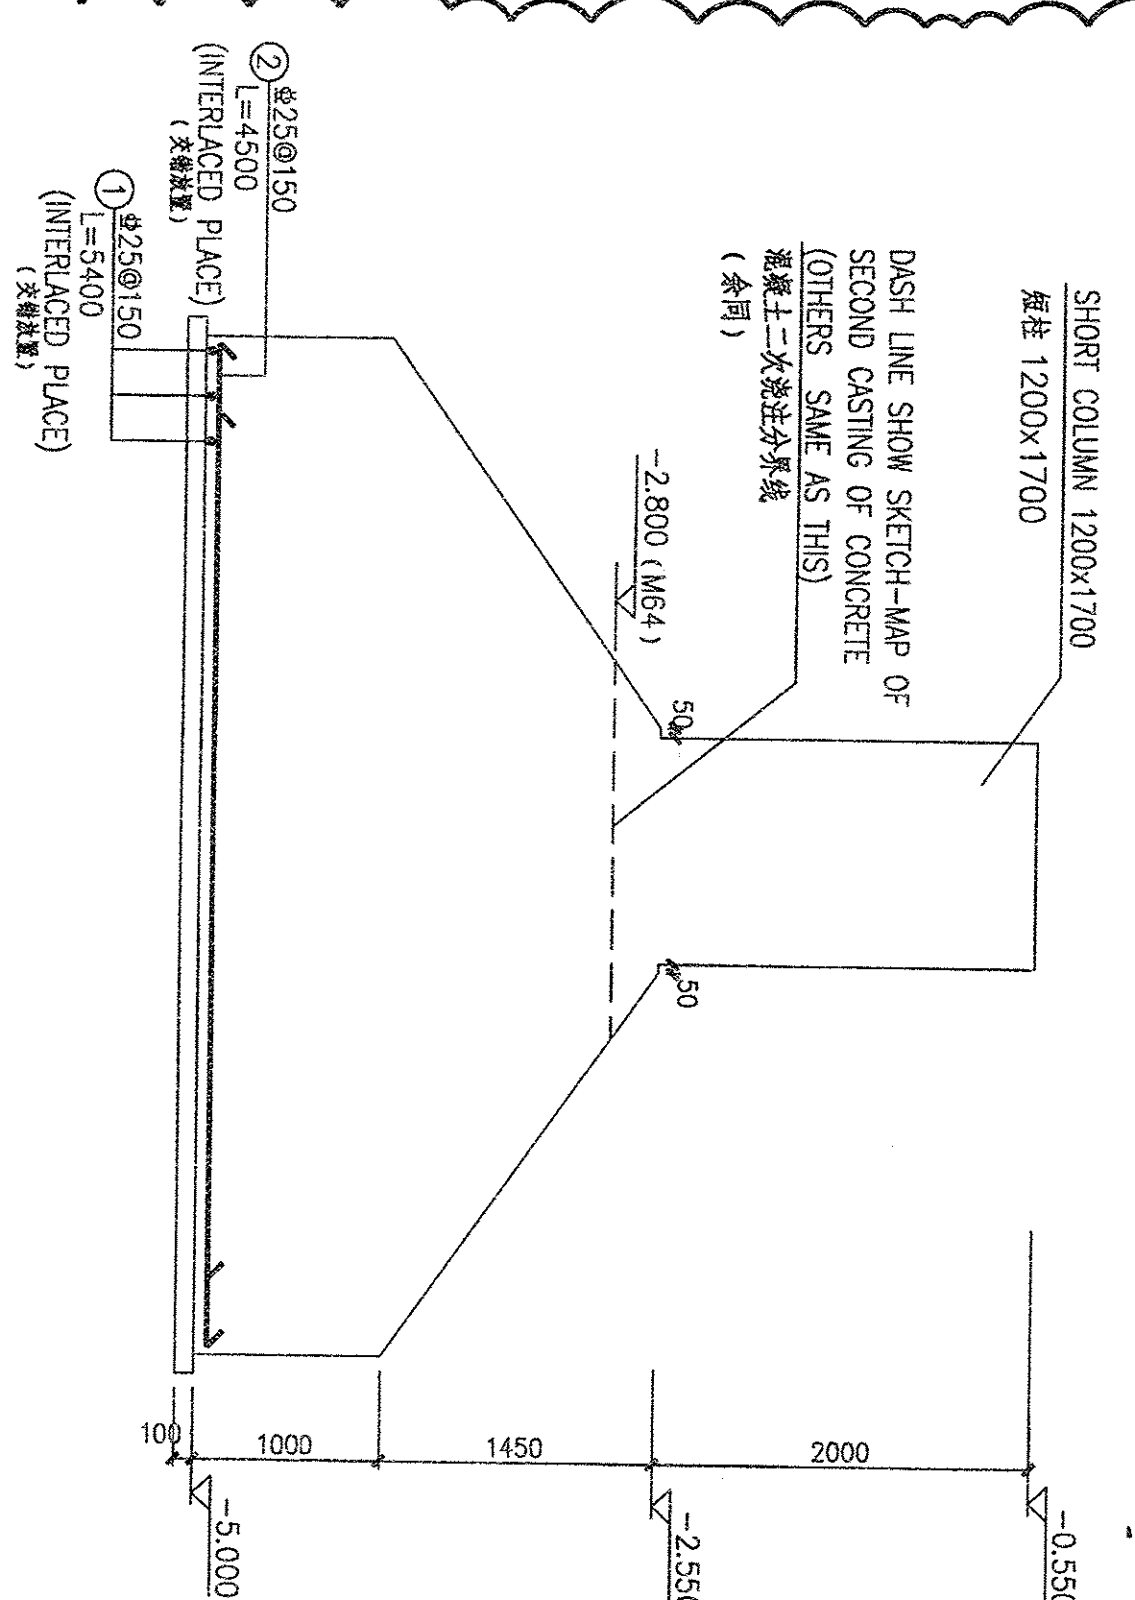
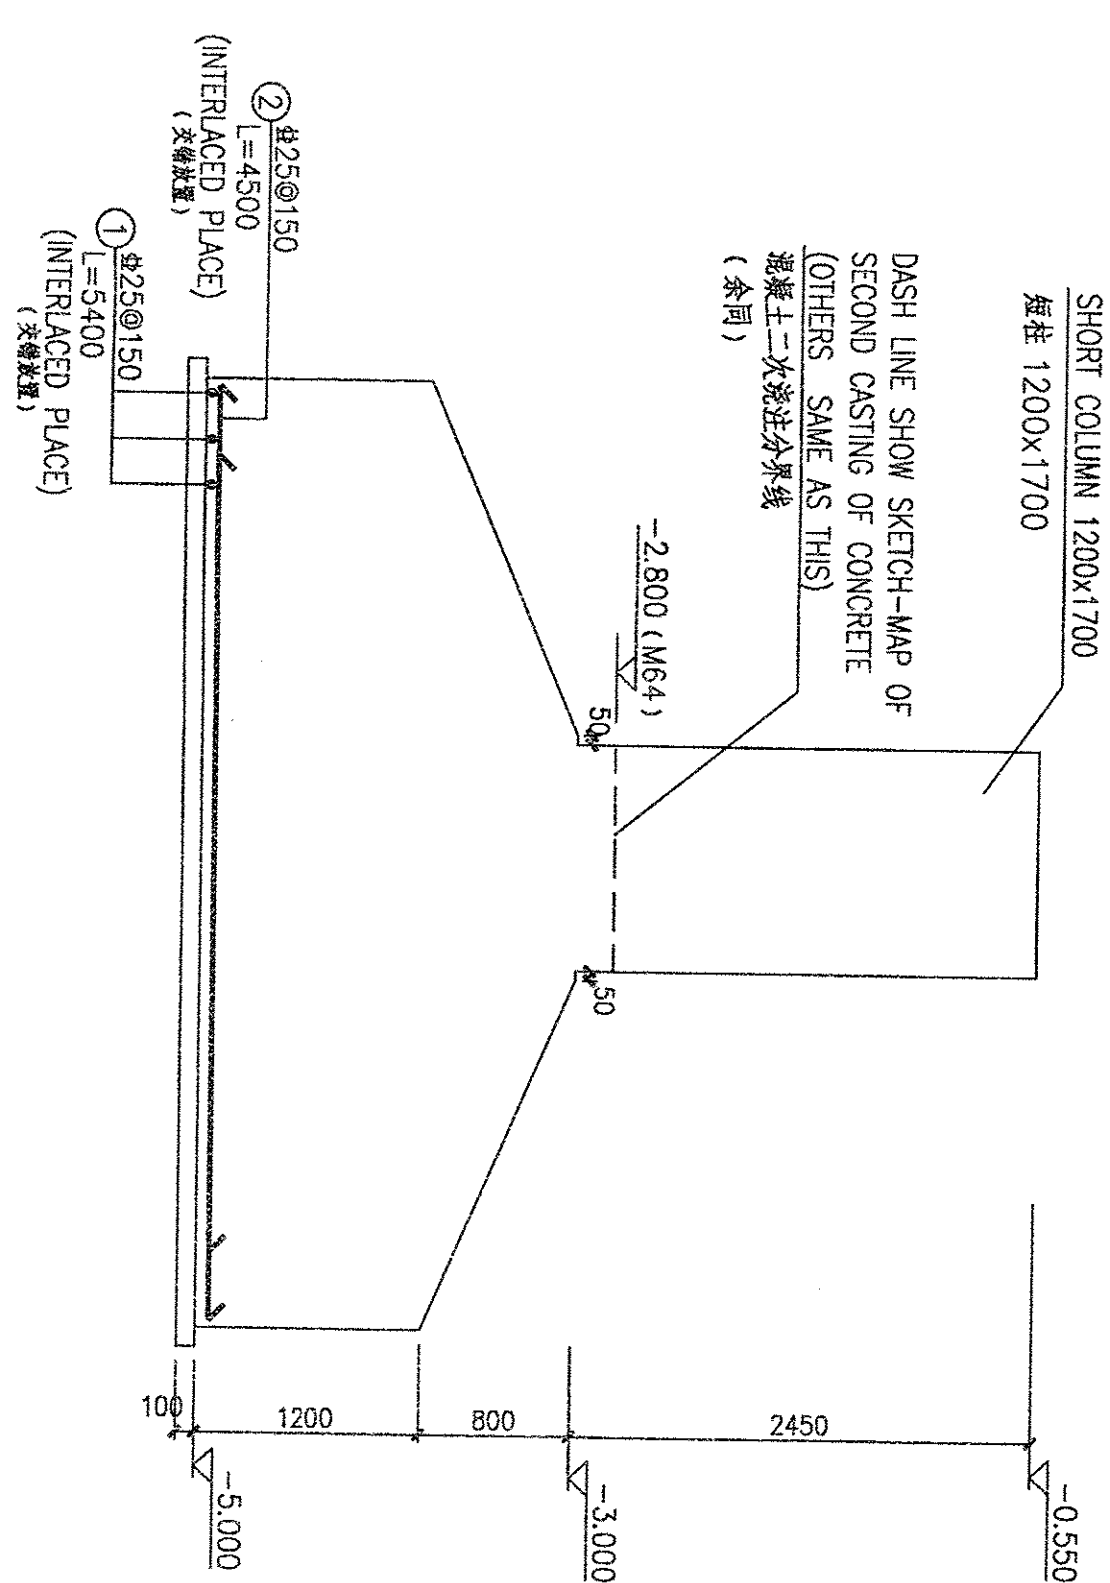


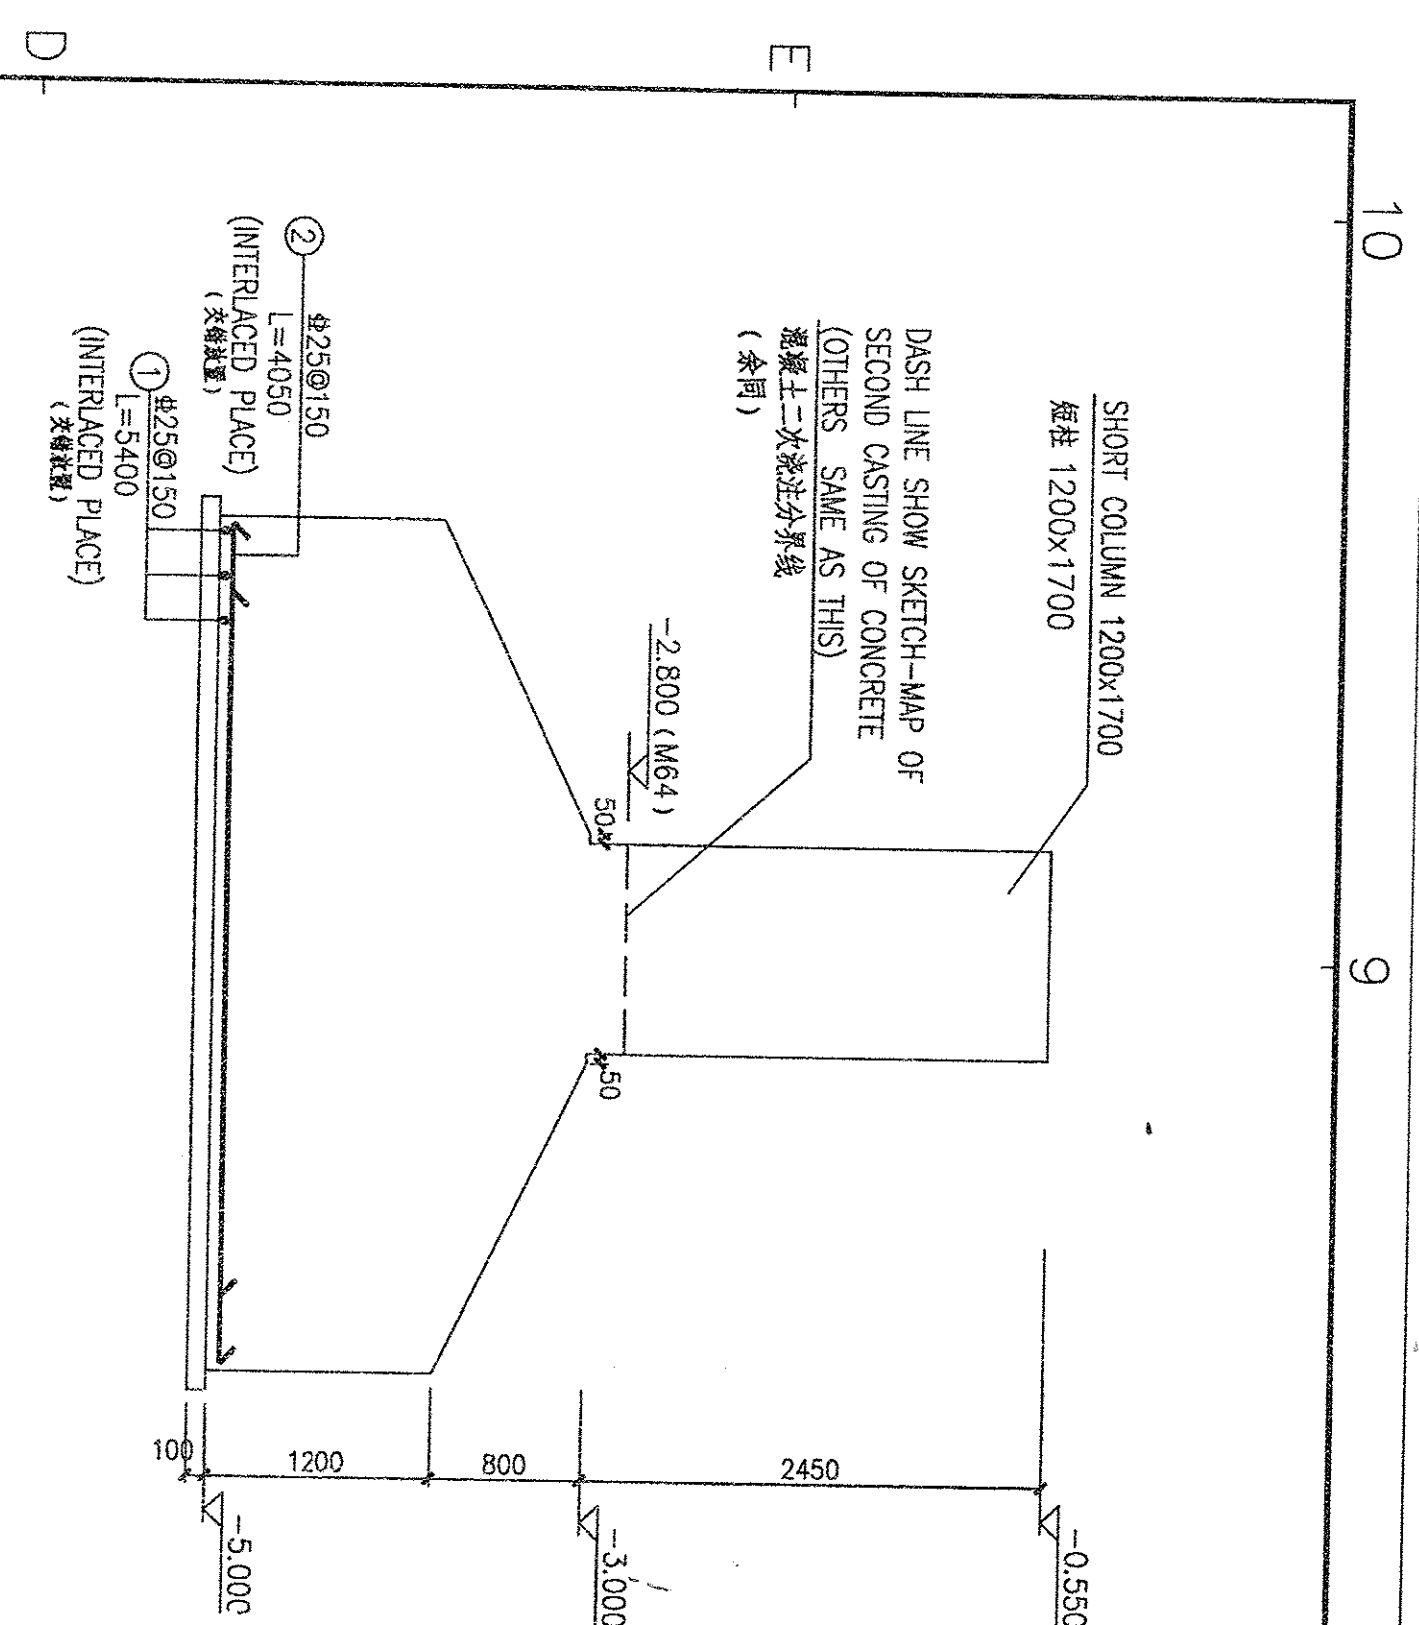

EPC		 山西电力勘测设计有限公司 SHANXI ELECTRIC POWER CONSTRUCTION CORPORATION	
CONTRACTOR :		STATE NUCLEAR ELECTRIC POWER PLANNING DESIGN INSTITUTE	
 STATE NUCLEAR ELECTRIC POWER PLANNING DESIGN INSTITUTE		KTHP-Q-SWDRH-JHF-01-0302(08)-B	
PROJECT CONTROL No.			
 STATE NUCLEAR ELECTRIC POWER PLANNING DESIGN & RESEARCH INSTITUTE			
PROJECT : 4.350MM KAMUANGA THERMAL POWER PROJECT			
APPRO. 何永茂			
DESIGN PHASE : DETAIL DESIGN			
P.W.M.D.			
CHKD. 李斌斌			
DSDD. 张永华			
SCALE 1:40			
DWG NO. 37-EA343S-70302-08			
REV.0			