
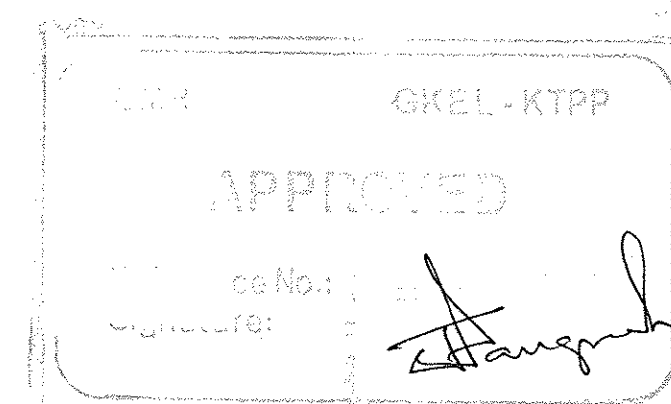


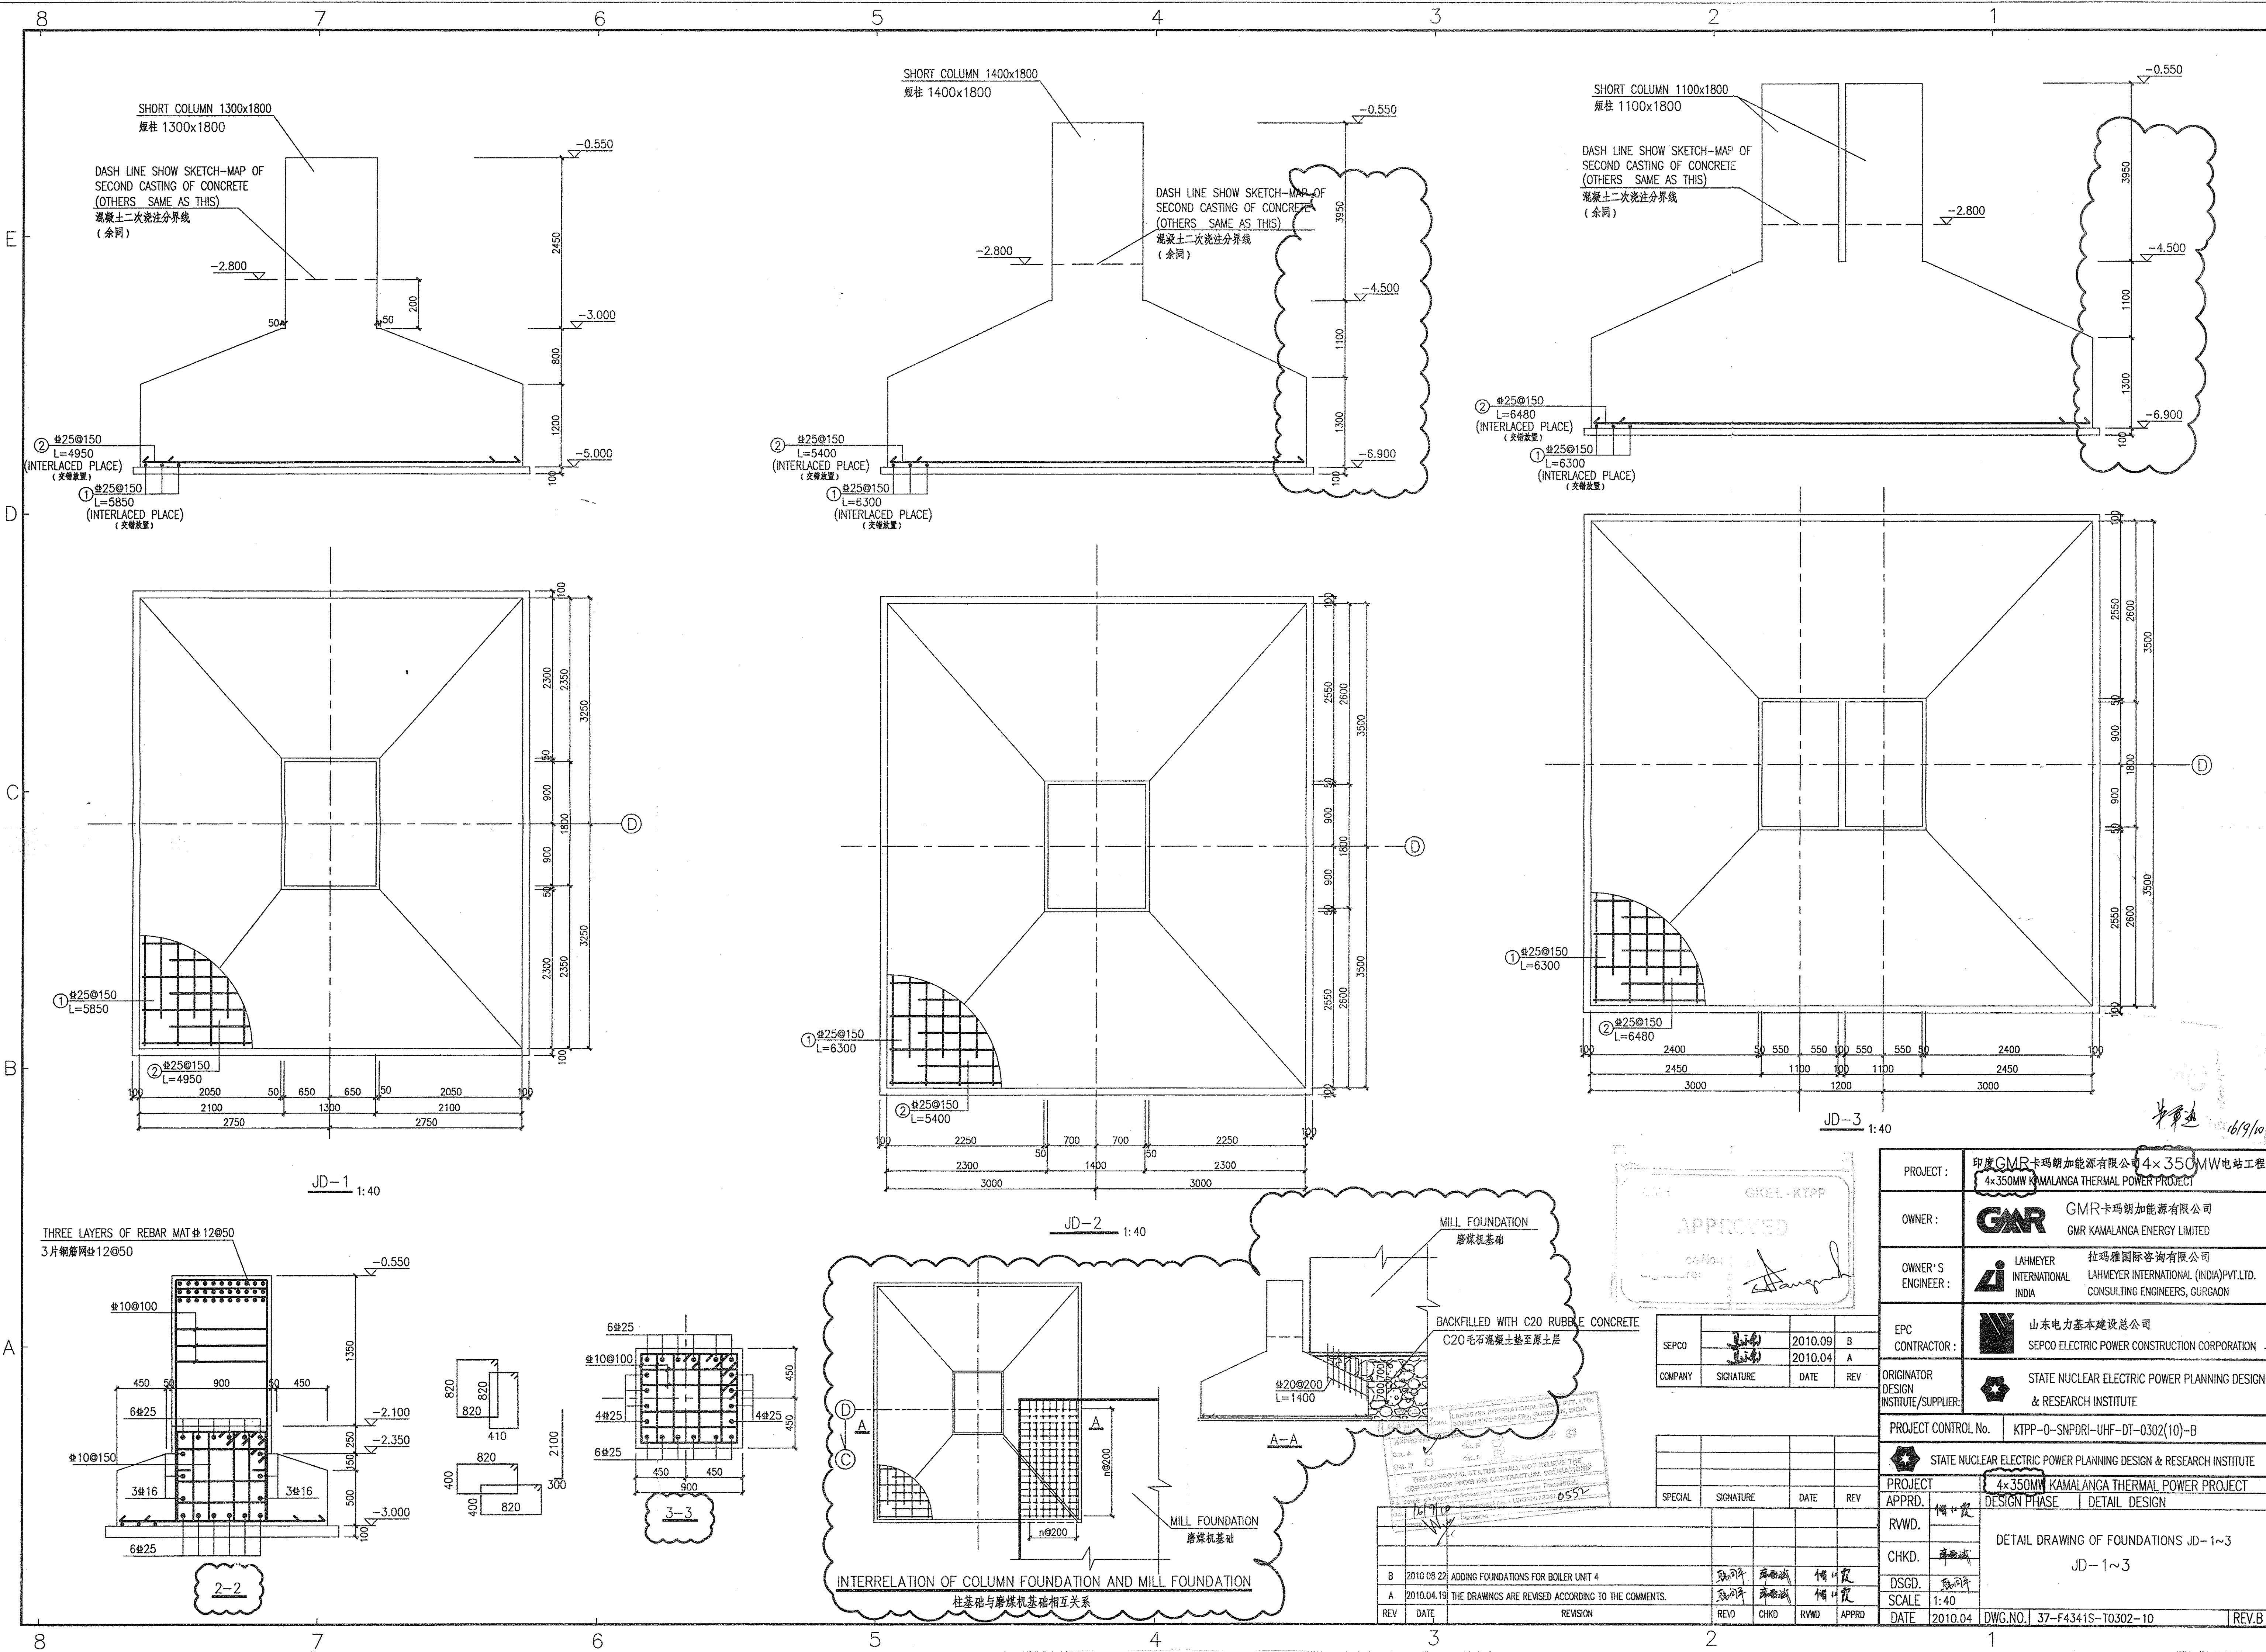

COMPANY	SIGNATURE	DATE	REV
SEPCC	2010.09.10	B	
2010.04.19	A		

SPECIAL	SIGNATURE	DATE	REV

PROJECT:	印度GMR卡玛朗加能源有限公司4x350MW电站工程 4x350MW KAMALANGA THERMAL POWER PROJECT
OWNER:	GMR 卡玛朗加能源有限公司 GMR KAMALANGA ENERGY LIMITED
OWNER'S ENGINEER:	LAHMEYER INTERNATIONAL CONSULTING ENGINEERS, GURGAON LAHMEYER INTERNATIONAL (INDIA) PVT. LTD.
EPC CONTRACTOR:	山东电力基本建设总公司 SEPCC ELECTRIC POWER CONSTRUCTION CORPORATION
ORIGINATOR DESIGN INSTITUTE/SUPPLIER:	STATE NUCLEAR ELECTRIC POWER PLANNING DESIGN & RESEARCH INSTITUTE
PROJECT CONTROL No.	KTPP-0-SNPDR-UHF-DT-0302(10)-B
PROJECT APPR.	4x350MW KAMALANGA THERMAL POWER PROJECT DESIGN PHASE: DETAIL DESIGN
RWD.	DETAIL DRAWING OF FOUNDATIONS JD-1~3
CHKD.	JD-1~3
DSGD.	
SCALE	1:40
DATE	2010.04
DWG. NO.	37-F4341S-T0302-10
REV. B	