

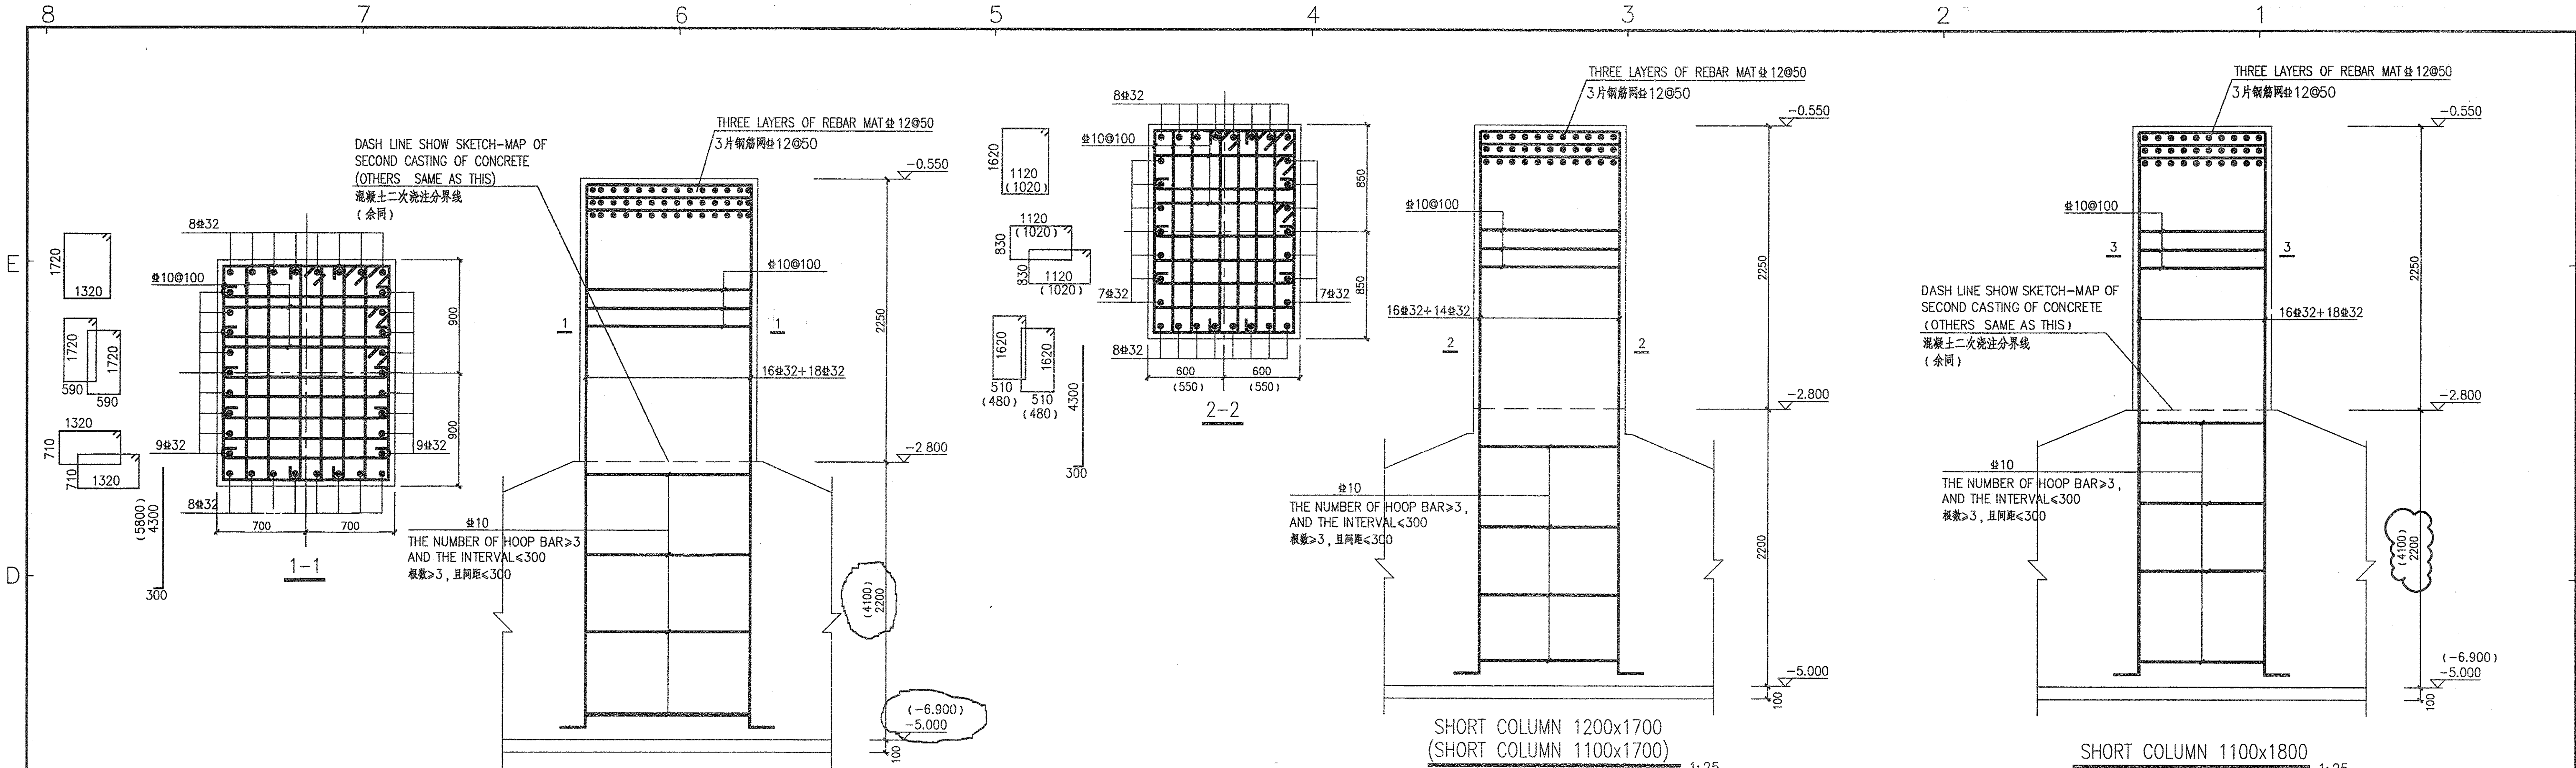
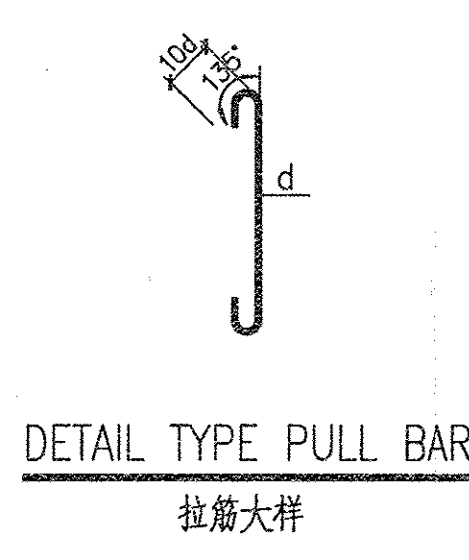


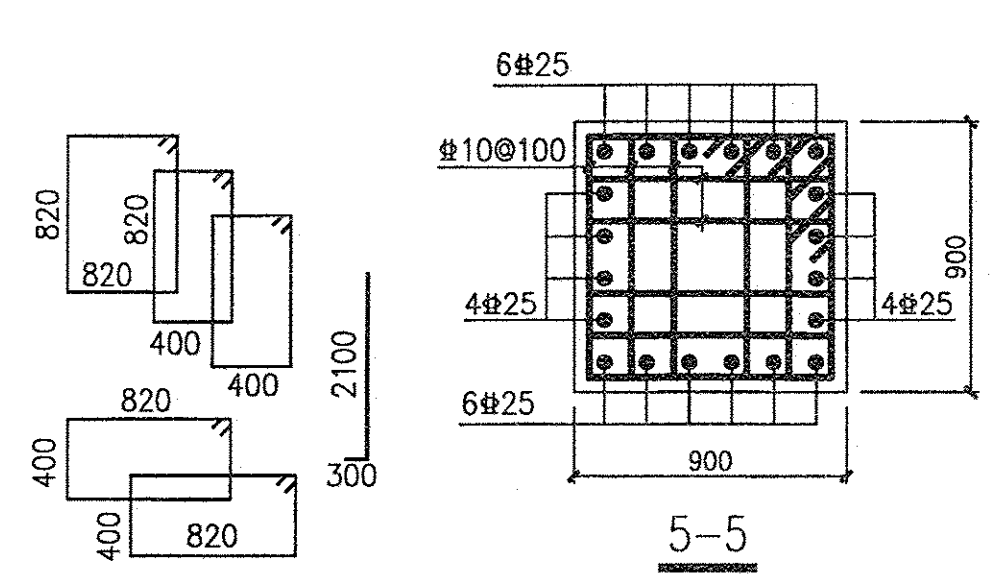

VALUES IN () BRACKETS INDICATED THE DIMENSION AND SIZE OF SHORT COLUMN ① AXIS
() 内数值表示①轴线的标注和尺寸

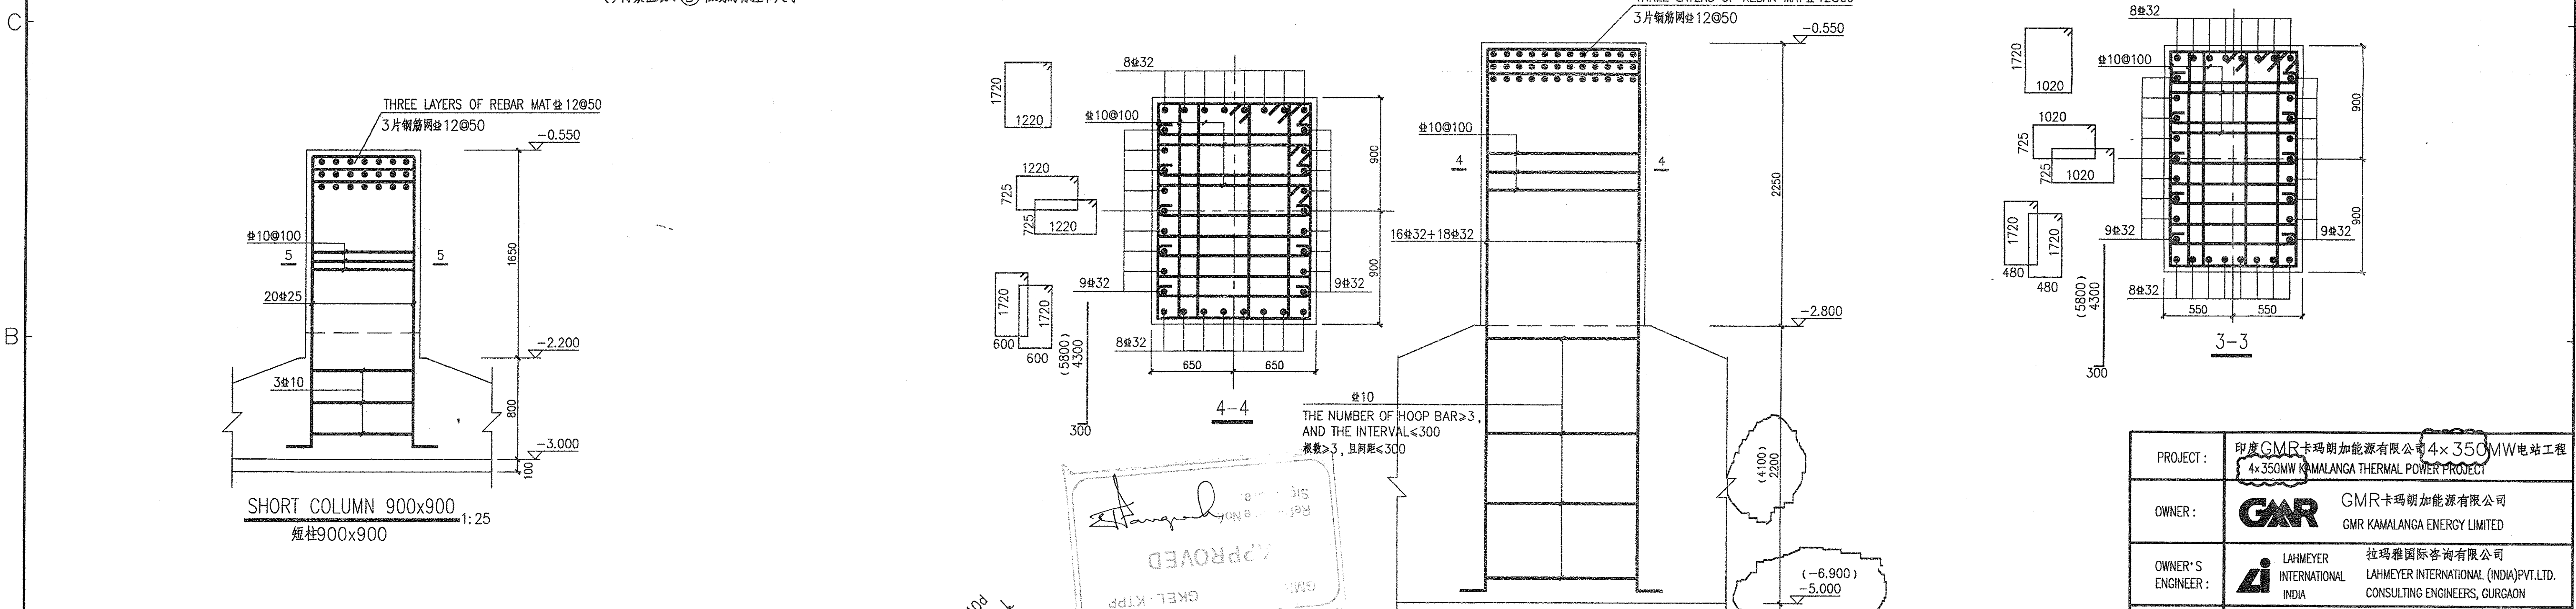

APPROVED
GKEL-KTPP

VALUES IN () BRACKETS INDICATED THE DIMENSION AND SIZE OF SHORT COLUMN ① AXIS
() 内数值表示①轴线的标注和尺寸

PROJECT:	印度GMR卡玛朗加能源有限公司4x350MW电站工程 4x350MW KAMALANGA THERMAL POWER PROJECT
OWNER:	GMR卡玛朗加能源有限公司 GMR KAMALANGA ENERGY LIMITED
OWNER'S ENGINEER:	LAHMEYER 拉玛雅国际咨询有限公司 LAHMEYER INTERNATIONAL (INDIA) PVT. LTD. CONSULTING ENGINEERS, GURGAON
EPC CONTRACTOR:	山东电力基本建设总公司 SEPCO ELECTRIC POWER CONSTRUCTION CORPORATION
ORIGINATOR DESIGN INSTITUTE/SUPPLIER:	STATE NUCLEAR ELECTRIC POWER PLANNING DESIGN & RESEARCH INSTITUTE
PROJECT CONTROL No.	KTPP-0-SNPDR-UIHF-DT-0302(11)-B
PROJECT APPR.	4x350MW KAMALANGA THERMAL POWER PROJECT DESIGN PHASE
RWD.	DETAIL DRAWING OF FOUNDATION'S SHORT COLUMN
CHKD.	基础短柱详图
DSGD.	SCALE 1:25
SCALE	1:25
DATE	2010.04
DWG. NO.	37-F4341S-T0302-11
REV.	REV. B