


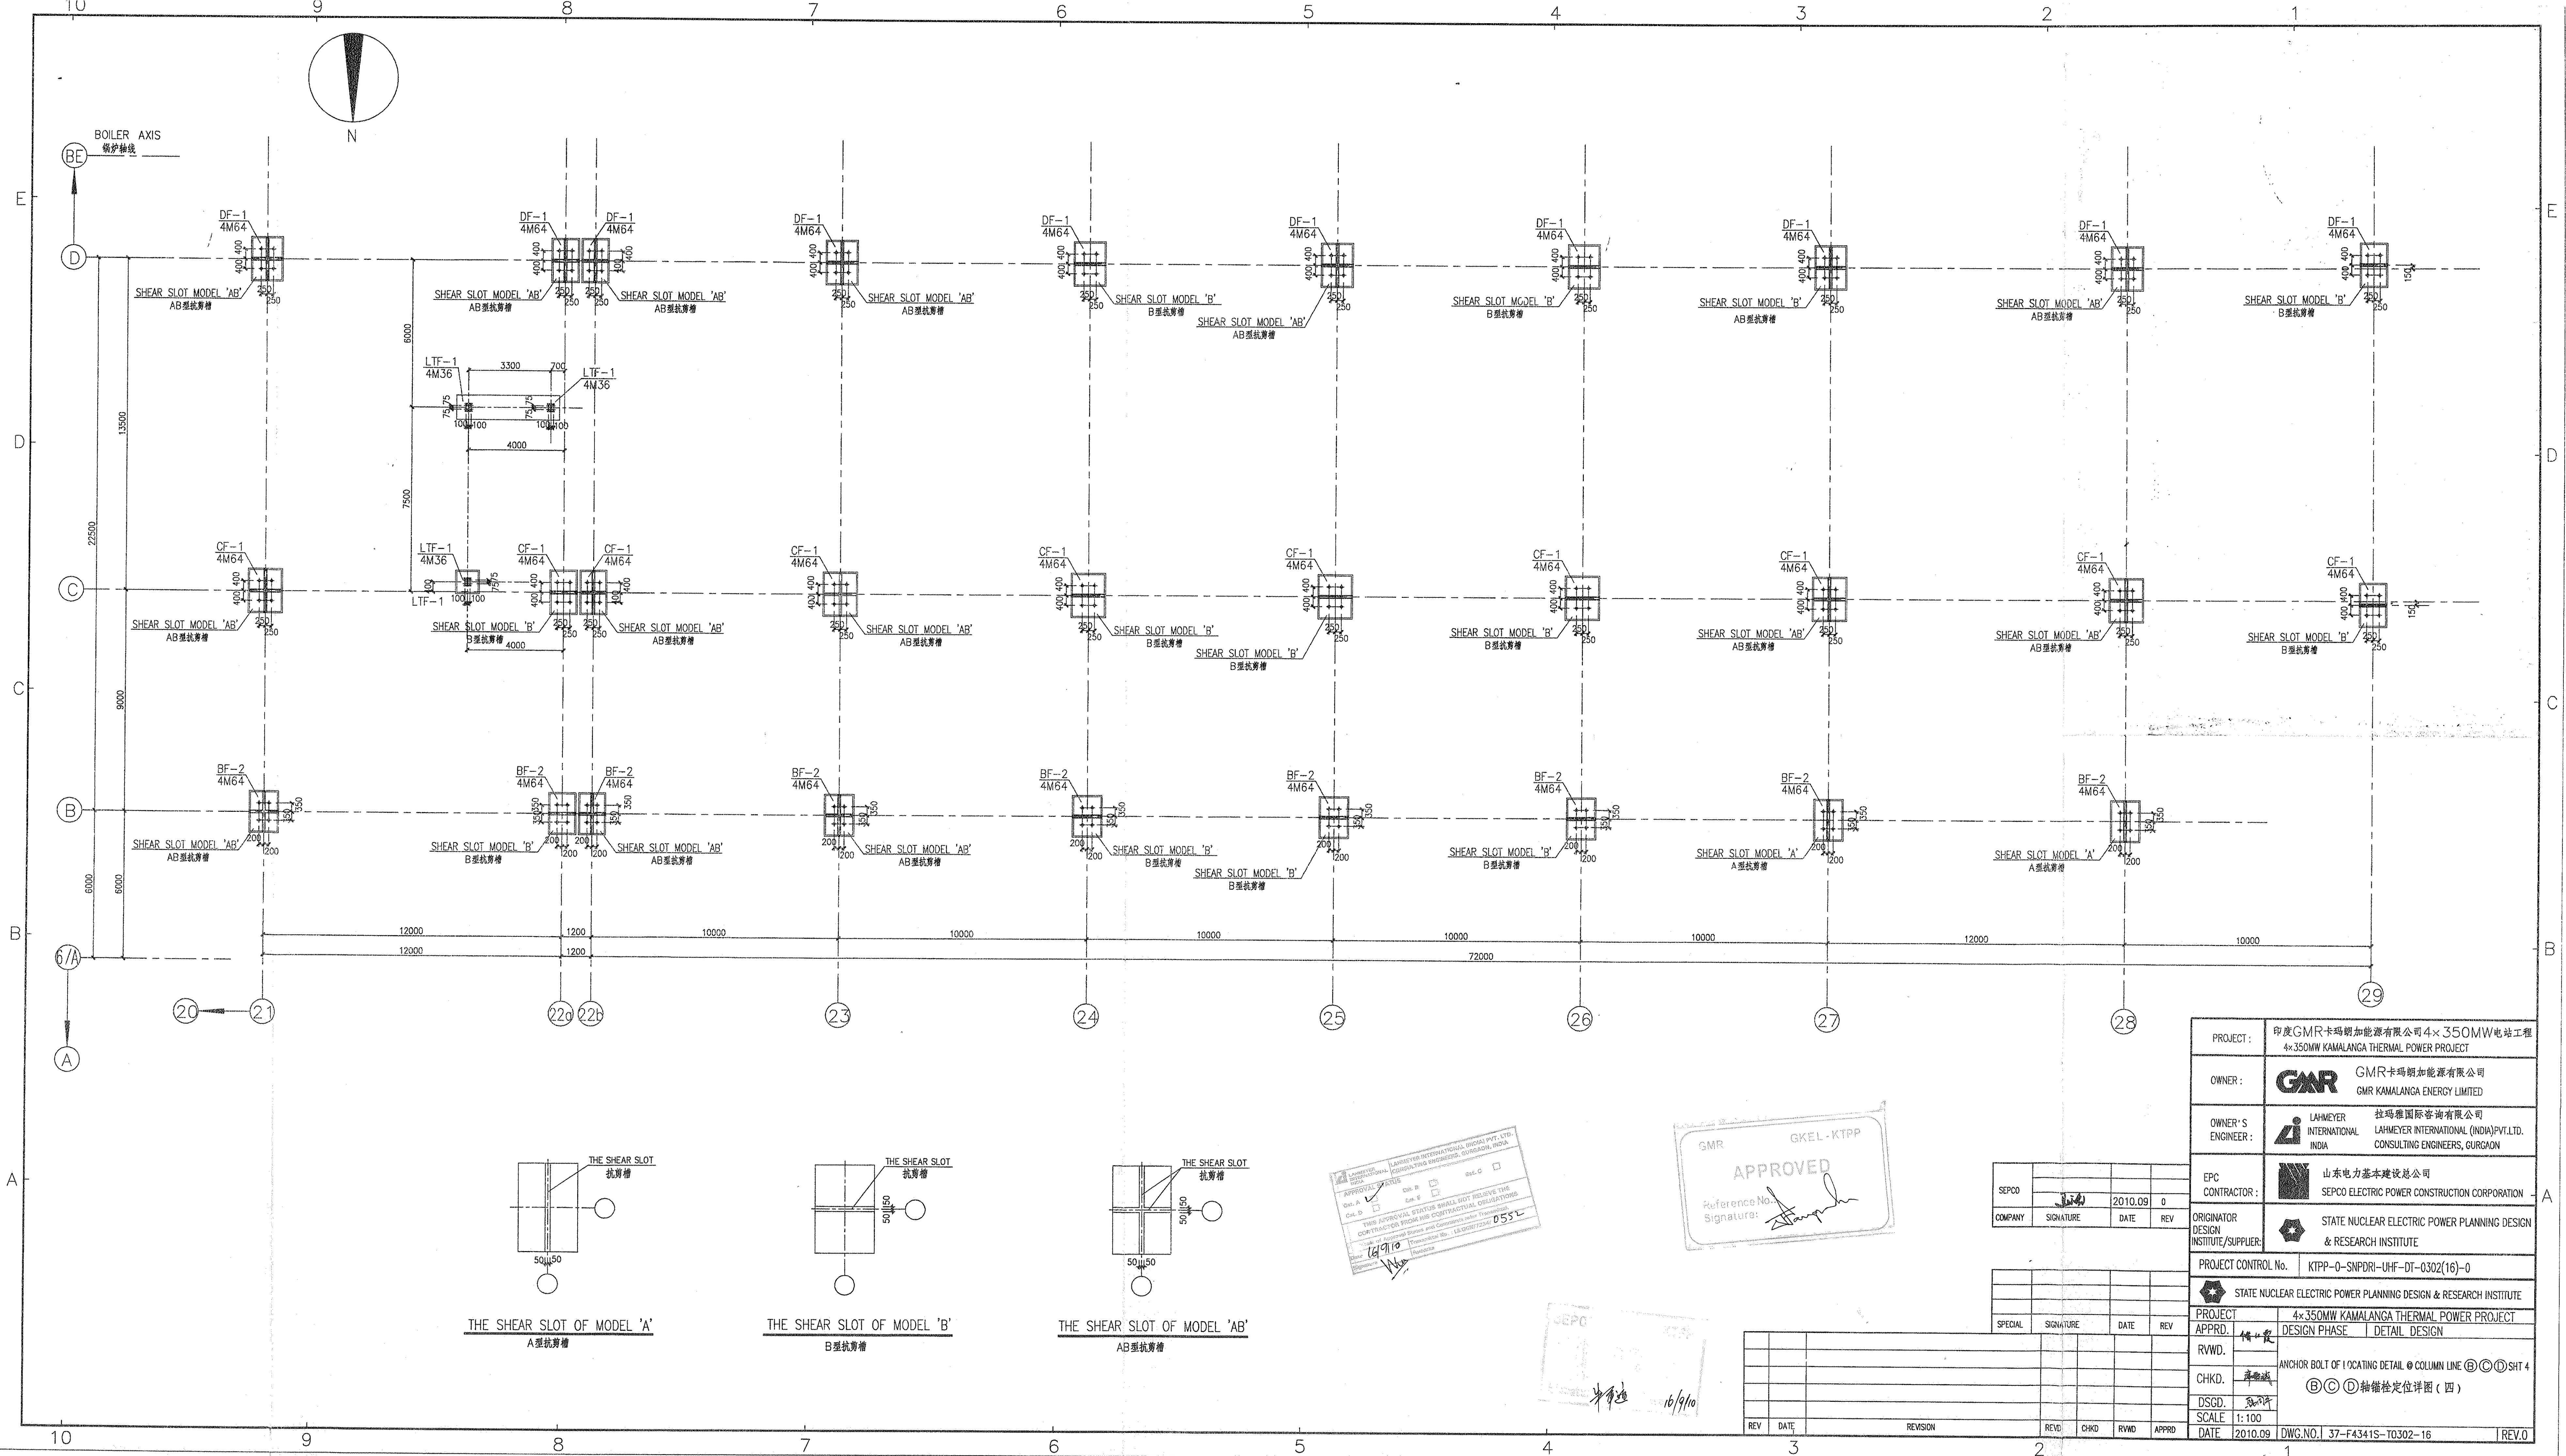

LAHMEYER INTERNATIONAL (INDIA) PVT. LTD.
CONSULTING ENGINEERS, GURGAON, INDIA
APPROVED
Reference No. 0552
Signature: [Signature]

GMR GKEL-KTPP
APPROVED
Reference No. [Blank]
Signature: [Signature]

SEPCO				
COMPANY	SIGNATURE	DATE	REV	
		2010.09	0	

SPECIAL	SIGNATURE	DATE	REV

REV	DATE	REVISION	REV	CHKD	RWD	APPRD

PROJECT:	印度GMR卡玛朗加能源有限公司4x350MW电站工程 4x350MW KAMALANGA THERMAL POWER PROJECT
OWNER:	GMR GMR卡玛朗加能源有限公司 GMR KAMALANGA ENERGY LIMITED
OWNER'S ENGINEER:	LAHMEYER 拉玛雅国际咨询有限公司 LAHMEYER INTERNATIONAL (INDIA) PVT. LTD. CONSULTING ENGINEERS, GURGAON
EPC CONTRACTOR:	SEPCO 山东电力基本建设总公司 SEPCO ELECTRIC POWER CONSTRUCTION CORPORATION
ORIGINATOR DESIGN INSTITUTE/SUPPLIER:	STATE NUCLEAR ELECTRIC POWER PLANNING DESIGN & RESEARCH INSTITUTE
PROJECT CONTROL No.	KTPP-0-SNPDR1-UHF-DT-0302(16)-0
PROJECT APPRD.	4x350MW KAMALANGA THERMAL POWER PROJECT DESIGN PHASE: 施工图设计 DETAIL DESIGN
RWD.	ANCHOR BOLT OF LOCATING DETAIL @ COLUMN LINE (B) ①②③④ SHT 4
CHKD.	③③③ 轴锚栓定位详图 (四)
DSGD.	
SCALE	1:100
DATE	2010.09
DWG. NO.	37-F4341S-T0302-16
REV.0	